

## AS BUILT DRAWINGS FOR: MOKUAIKAUA CHURCH

PROJECT DATA	
LOT AREA (PARCEL 18)	.810 ACRES
LOT AREA (PARCEL 45)	7,232 SQ FT
SANTUARY AREA (1ST FLOOR)	5,820 SQ FT
SANTUARY AREA (2ND FLOOR)	3,616 SQ FT
SANCTUARY AREA (TOTAL)	9,436 SQ FT

SHEET INDEX		
NBR.	SHEET	DESCRIPTION
1	G1	EXTERIOR PERSPECTIVE
2	A1	FLOOR PLAN (1ST FLOOR)
3	A2	FLOOR PLAN (2ND FLOOR)
4	A3	EXTERIOR ELEVATIONS
5	A4	EXTERIOR ELEVATIONS
6	A5	EXTERIOR ELEVATIONS
7	A6	SECTIONS
8	A7	INTERIOR ELEVATIONS
9	A8	INTERIOR ELEVATIONS
10	A9	INTERIOR ELEVATIONS
11	A10	REFLECTED CEILING PLAN (1ST FLOOR)
12	A11	REFLECTED CEILING PLAN (2ND FLOOR)
13	E1	ELECTRICAL PLAN (1ST FLOOR)
14	E2	ELECTRICAL PLAN (2ND FLOOR)

REVISIONS	BY

**PIPER DESIGNS**

Pete Piper  
75-5044 Kailua Hwy, #2  
Kailua-Kona, HI 96740  
331-2244

AS BUILT DRAWINGS FOR:  
**MOKUAIKAUA CHURCH**  
KAILUA-KONA, HAWAII  
T.M.K. (3) 7-5-07:18 & 45


DRAWN: PJP	JOB #: 2006-009
DATE: 2/21/2007	
SCALE: N/A	
DRAWING: EXTERIOR PERSPECTIVE	
SHEET	

1

1 OF 14 SHEETS

REVISIONS	BY

**PIPER DESIGNS**  
 Pete Piper  
 75-5444 Kailua Hwy, #2  
 Kailua-Kona, HI 96740  
 331-2244

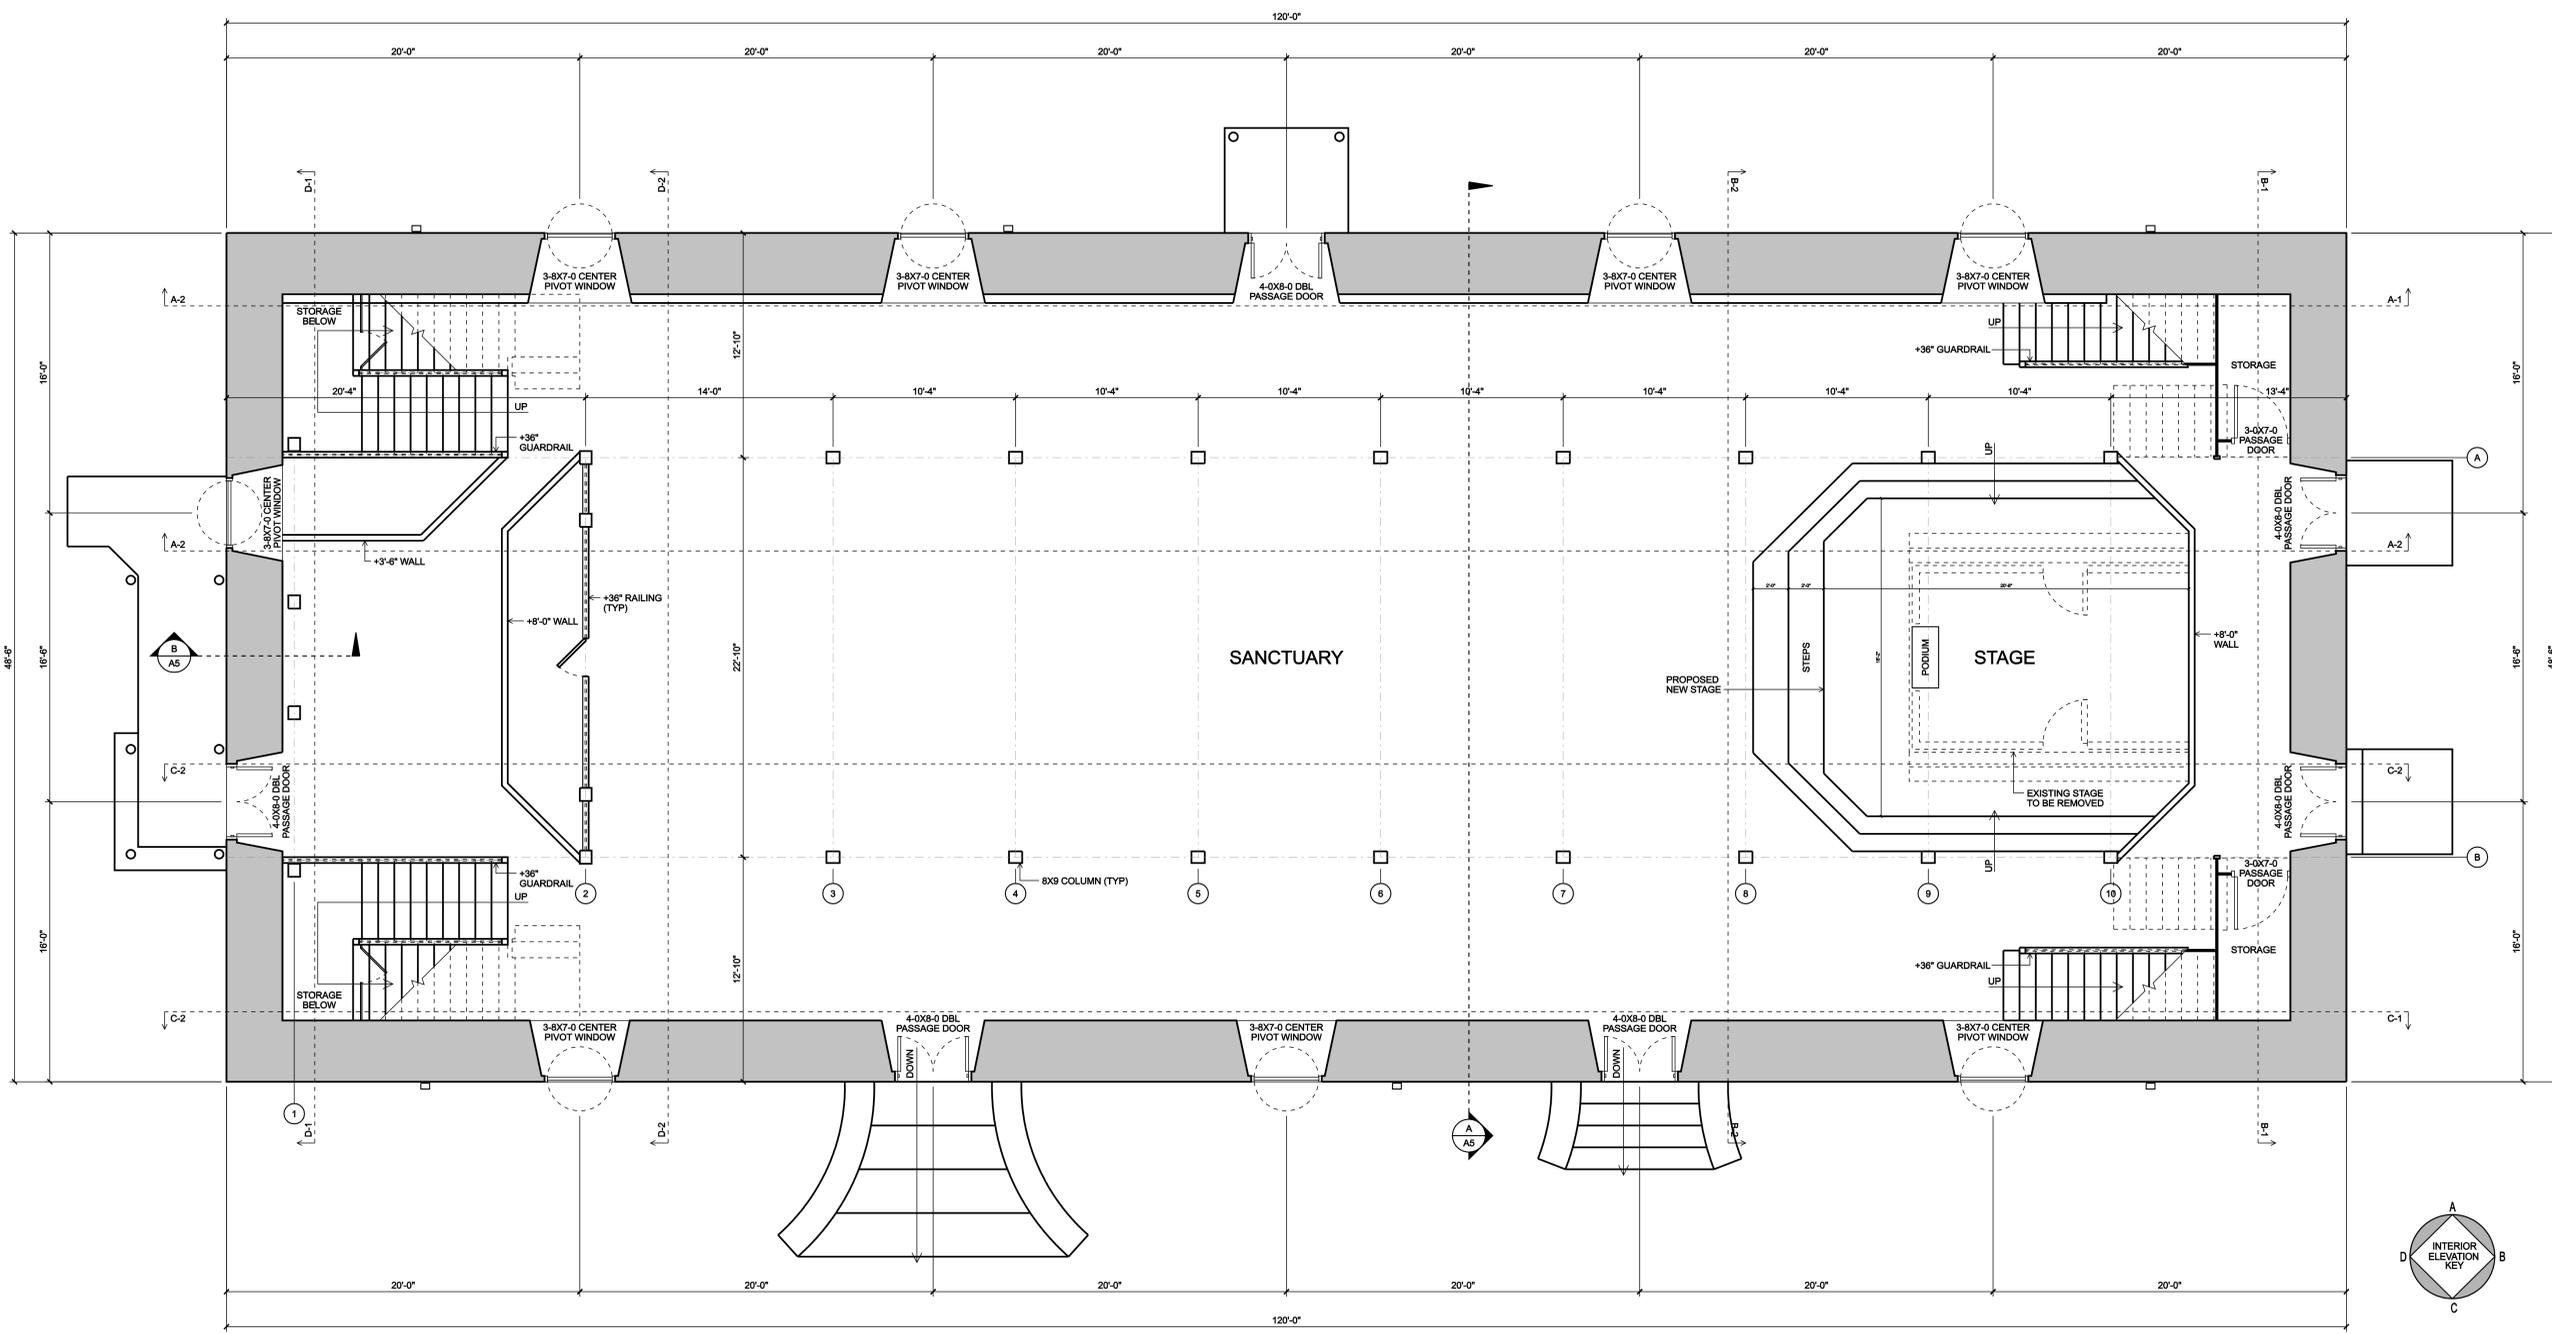

**FLOOR PLAN (1ST FLOOR)**  
 SCALE: 1/4"=1'-0"


AS BUILT DRAWINGS FOR:  
**MOKUAIKAUA CHURCH**  
 KAILUA-KONA, HAWAII  
 T.M.K. (3) 7-5-07:18 & 45

DRAWN: PJP	JOB #: 2006-009
DATE: 2/21/2007	
SCALE: 1/4"=1'-0"	
DRAWING: FLOOR PLAN (1ST FLOOR)	
SHEET	

**A1**  
 2 OF 14 SHEETS

REVISIONS	BY

**PIPER DESIGNS**  
 Pete Piper  
 75-5044 Kailua Hwy, #2  
 Kailua-Kona, HI 96740  
 331-2244

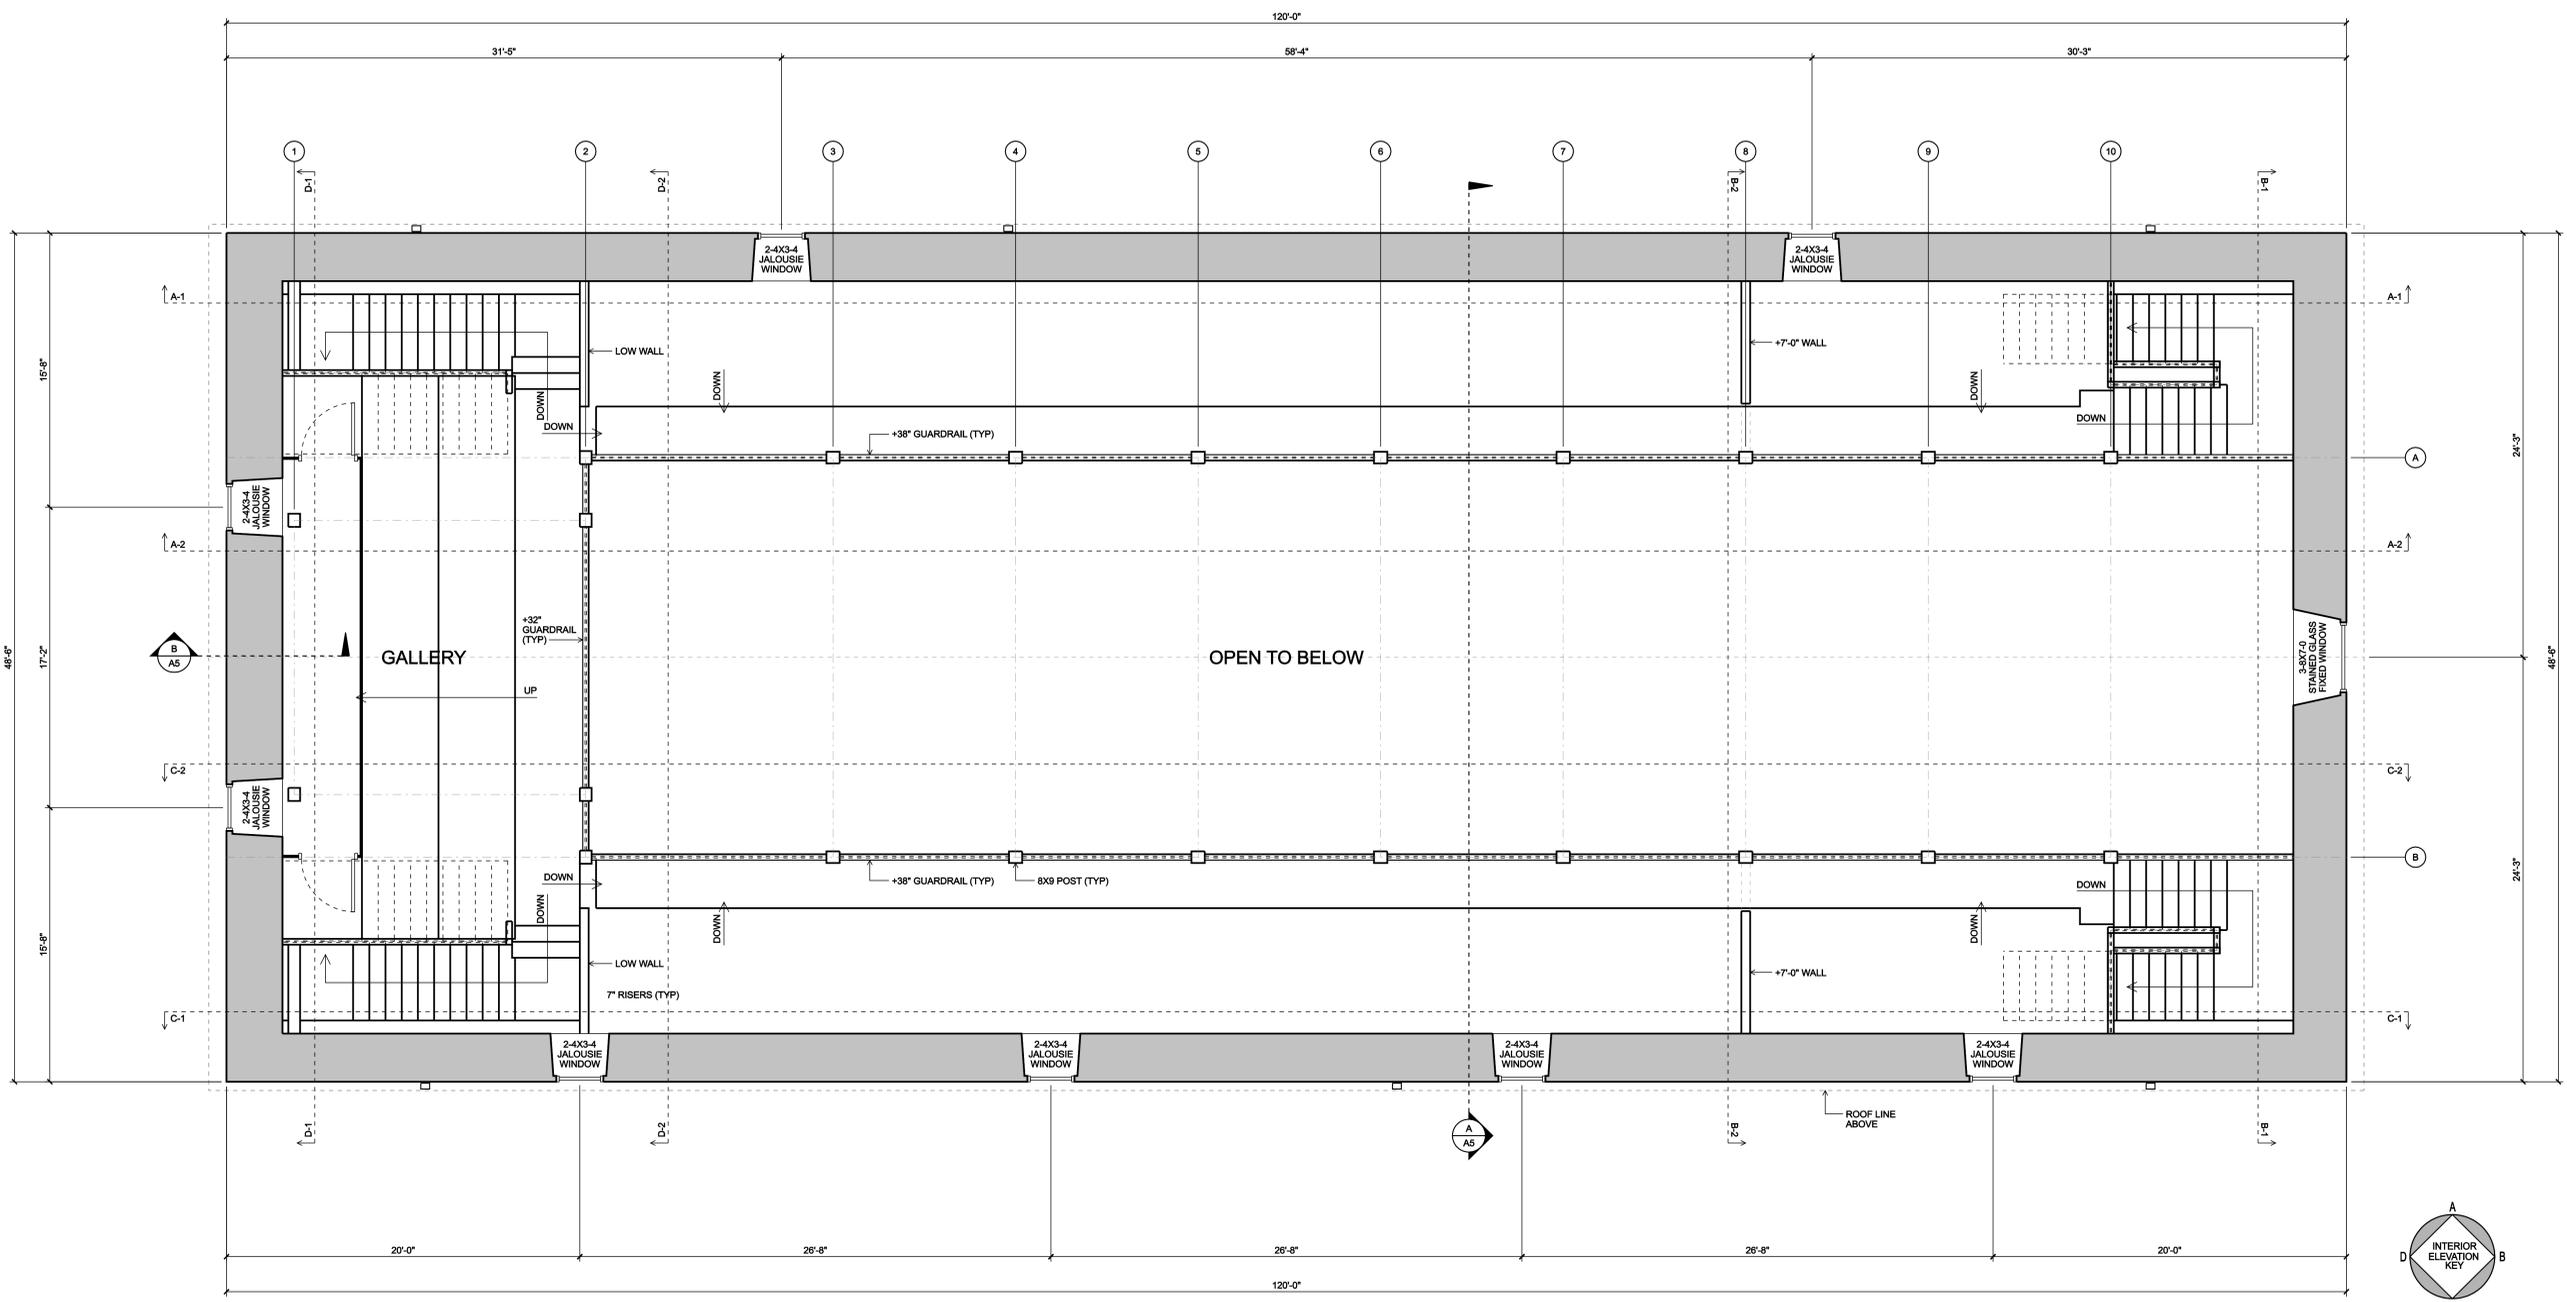

**FLOOR PLAN (2ND FLOOR)**  
 SCALE: 1/4"=1'-0"

AS BUILT DRAWINGS FOR:  
**MOKUAIKAUA CHURCH**  
 KAILUA-KONA, HAWAII  
 T.M.K. (3) 7-5-07:18 & 45

DRAWN: PJP	JOB #: 2006-009
DATE: 2/21/2007	
SCALE: 1/4"=1'-0"	
DRAWING: FLOOR PLAN (2ND FLOOR)	
SHEET	

**A2**  
 3 OF 14 SHEETS



**FRONT ELEVATION**

SCALE: 1/4"=1'-0"

REVISIONS	BY

**PIPER DESIGNS**

Pete Piper  
75-5044 Kailua Hwy, #2  
Kailua-Kona, HI 96740  
331-2244

AS BUILT DRAWINGS FOR:  
**MOKUAIKAIA CHURCH**  
KAILUA-KONA, HAWAII  
T.M.K. (3) 7-5-07:18 & 45


DRAWN: PJP	JOB #: 2006-009
DATE: 2/21/2007	
SCALE: 1/4"=1'-0"	
DRAWING: EXTERIOR ELEVATIONS	
SHEET	
<b>A3</b>	
4 OF 14 SHEETS	

REVISIONS	BY


**PIPER DESIGNS**  
 Pete Piper  
 75-5044 Kailua Hwy, #2  
 Kailua-Kona, HI 96740  
 331-2244

AS BUILT DRAWINGS FOR:  
**MOKUAIKAUA CHURCH**  
 KAILUA-KONA, HAWAII  
 T.M.K. (3) 7-5-07:18 & 45

DRAWN: PJP    JOB #: 2006-009  
 DATE: 2/21/2007  
 SCALE: 1/4"=1'-0"  
 DRAWING: EXTERIOR ELEVATIONS  
 SHEET  
**A4**  
 5 OF 14 SHEETS

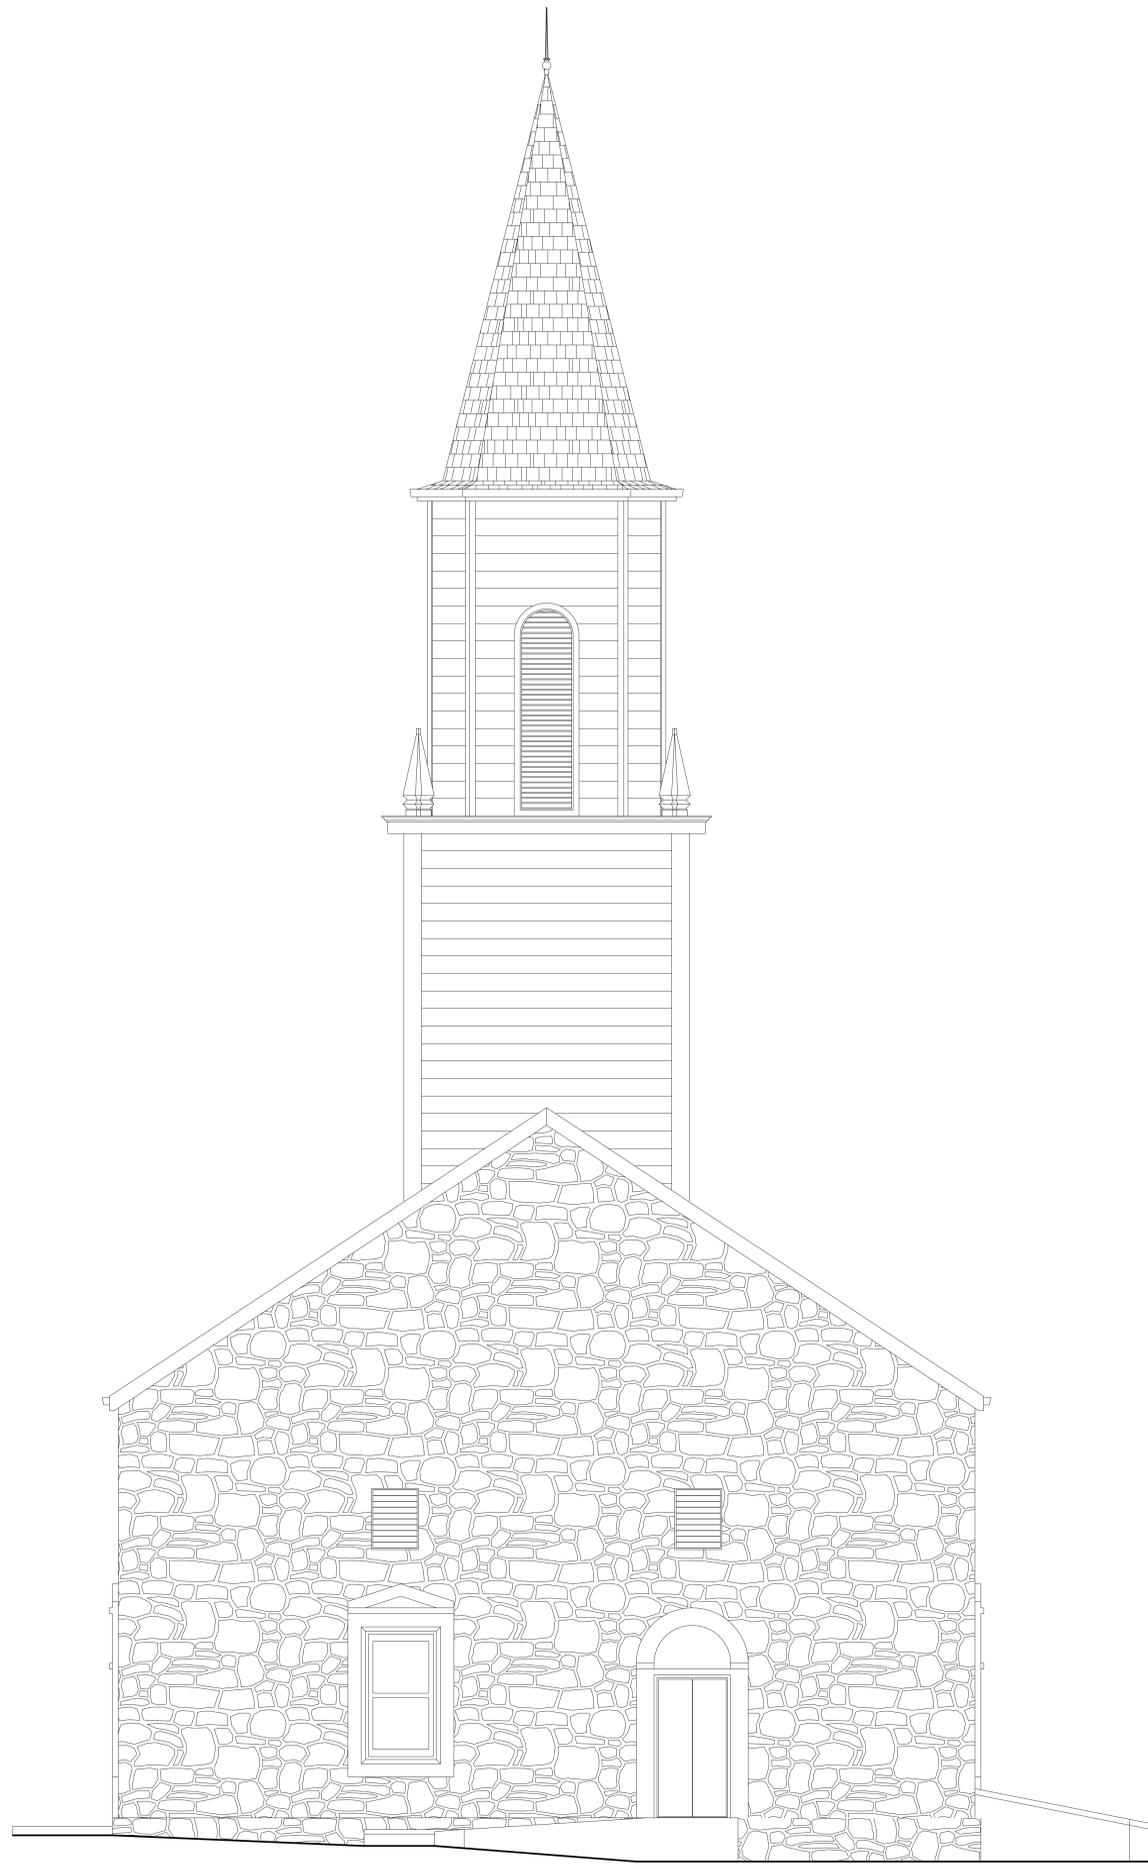

**LEFT ELEVATION**  
 SCALE: 1/4"=1'-0"

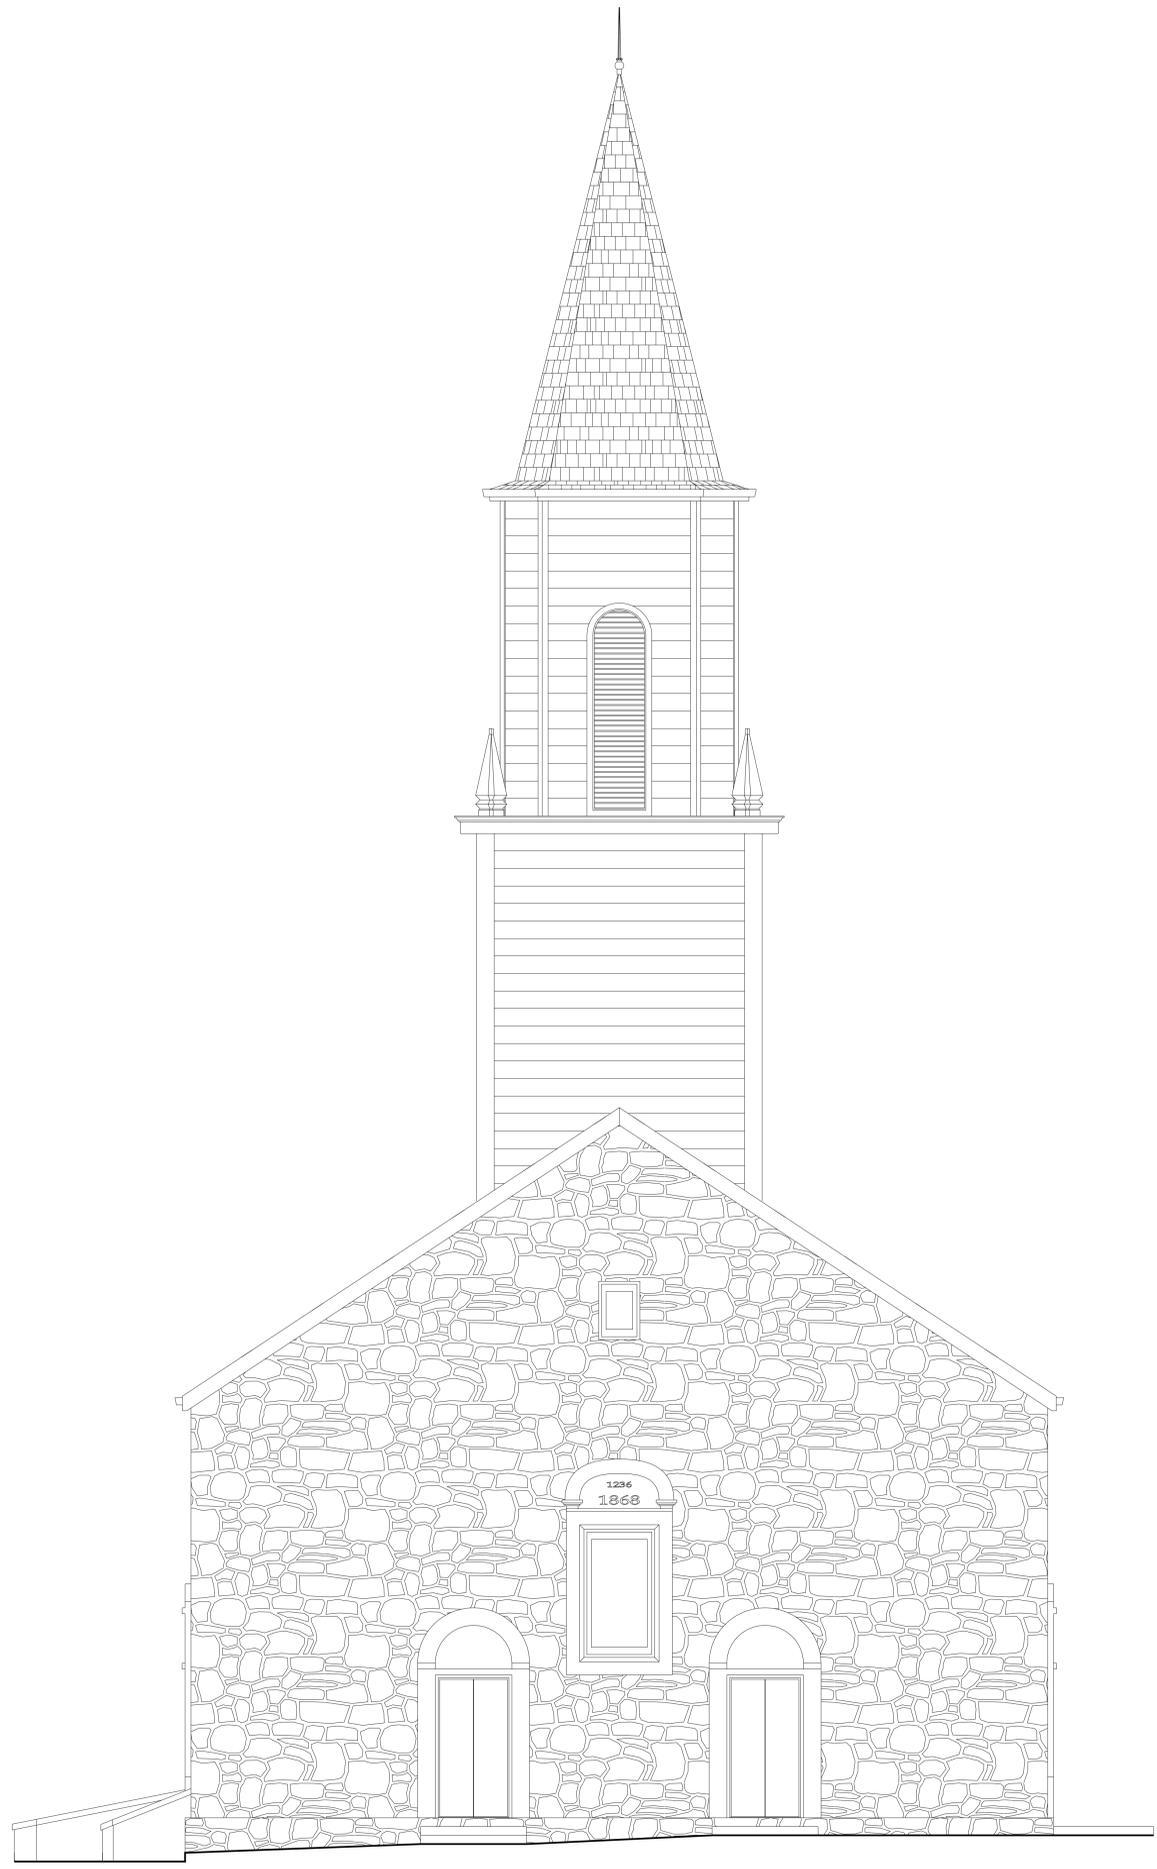

**RIGHT ELEVATION**  
 SCALE: 1/4"=1'-0"



**REAR ELEVATION**

SCALE: 1/4"=1'-0"

REVISIONS	BY

**PIPER DESIGNS**  
 Pete Piper  
 75-5044 Kailua Hwy, #2  
 Kailua-Kona, HI 96740  
 331-2244

AS BUILT DRAWINGS FOR:  
**MOKUAIKAIA CHURCH**  
 KAILUA-KONA, HAWAII  
 T.M.K. (3) 7-5-07:18 & 45

DRAWN: PJP  
 JOB #: 2006-009  
 DATE: 2/21/2007  
 SCALE: 1/4"=1'-0"  
 DRAWING:  
 EXTERIOR ELEVATIONS  
 SHEET


**A5**  
 6 OF 14 SHEETS

REVISIONS	BY


**PIPER DESIGNS**  
 Pete Piper  
 75-5044 Kailua-Hwy, #2  
 Kailua-Kona, HI 96740  
 331-2244

AS BUILT DRAWINGS FOR:  
**MOKUAIKAUA CHURCH**  
 KAILUA-KONA, HAWAII  
 T.M.K. (3) 7-5-07:18 & 45

DRAWN: PJP	JOB #: 2008-009
DATE: 2/21/2007	
SCALE: AS NOTED	
DRAWING: SECTIONS	
SHEET	
<b>A5</b>	
6 OF 14 SHEETS	

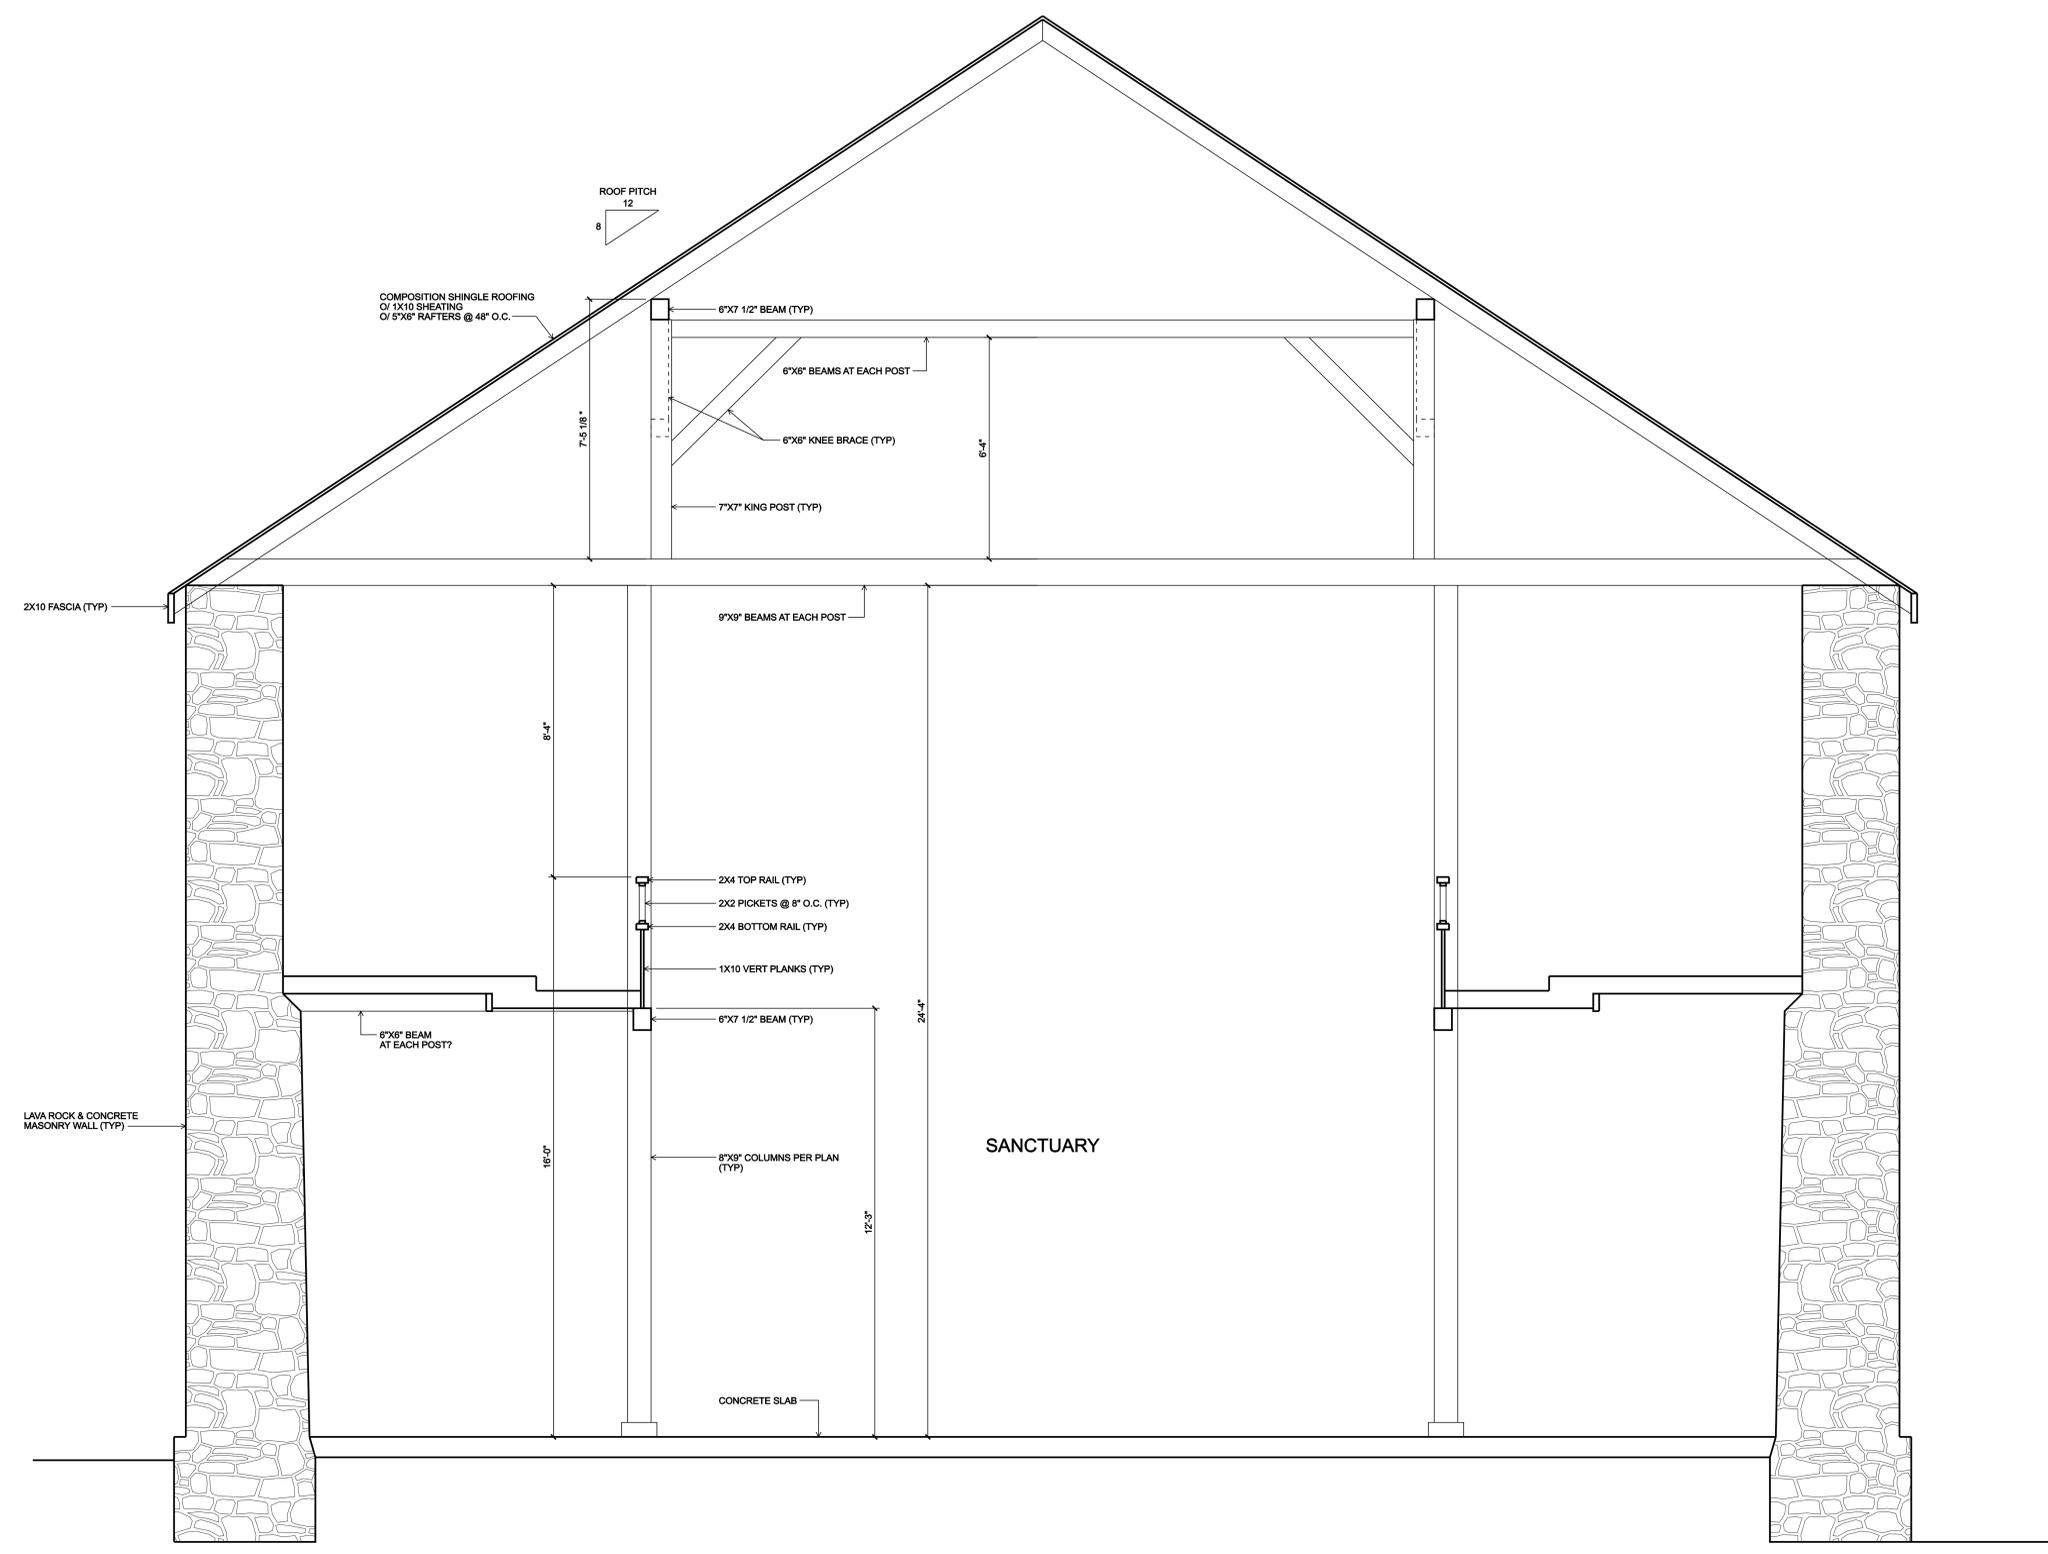

**SECTION**  
 SCALE: 1/2"=1'-0"

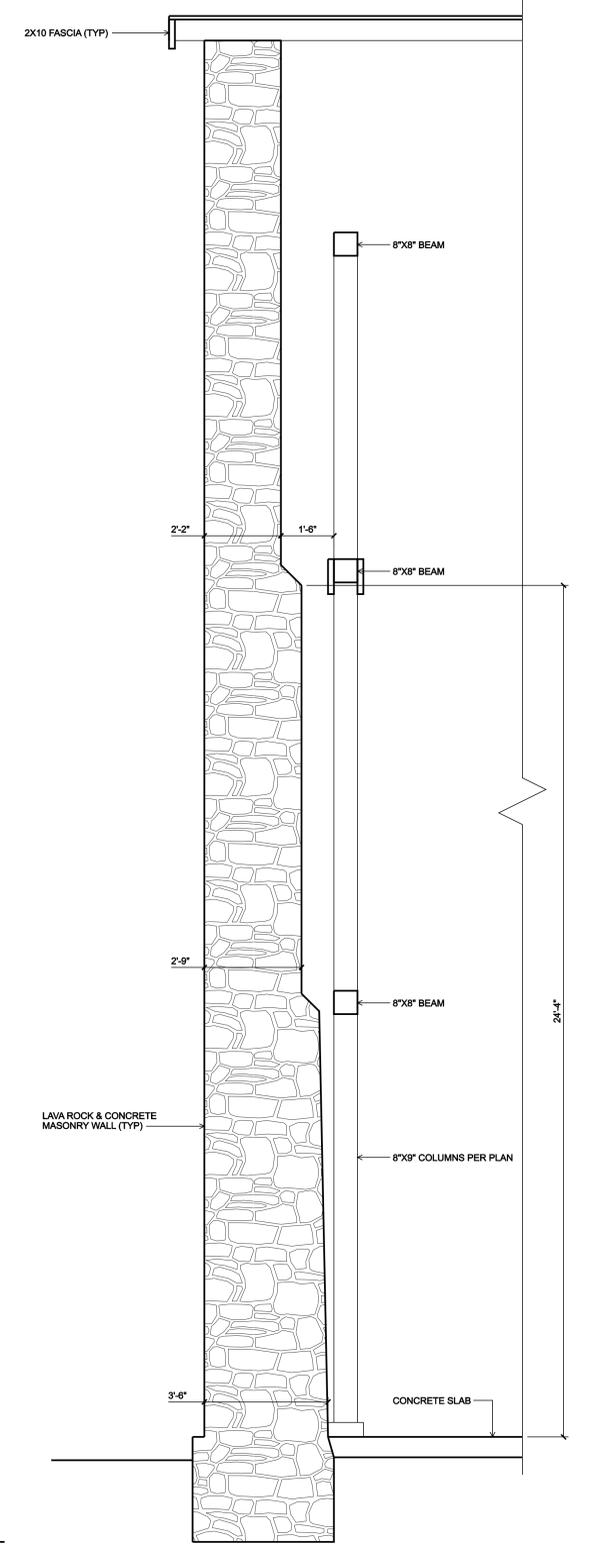


**SECTION**  
 SCALE: 1/2"=1'-0"


REVISIONS	BY

**PIPER DESIGNS**

Pete Piper  
75-5444 Kailua Hwy, #2  
Kailua-Kona, HI 96740  
331-2244

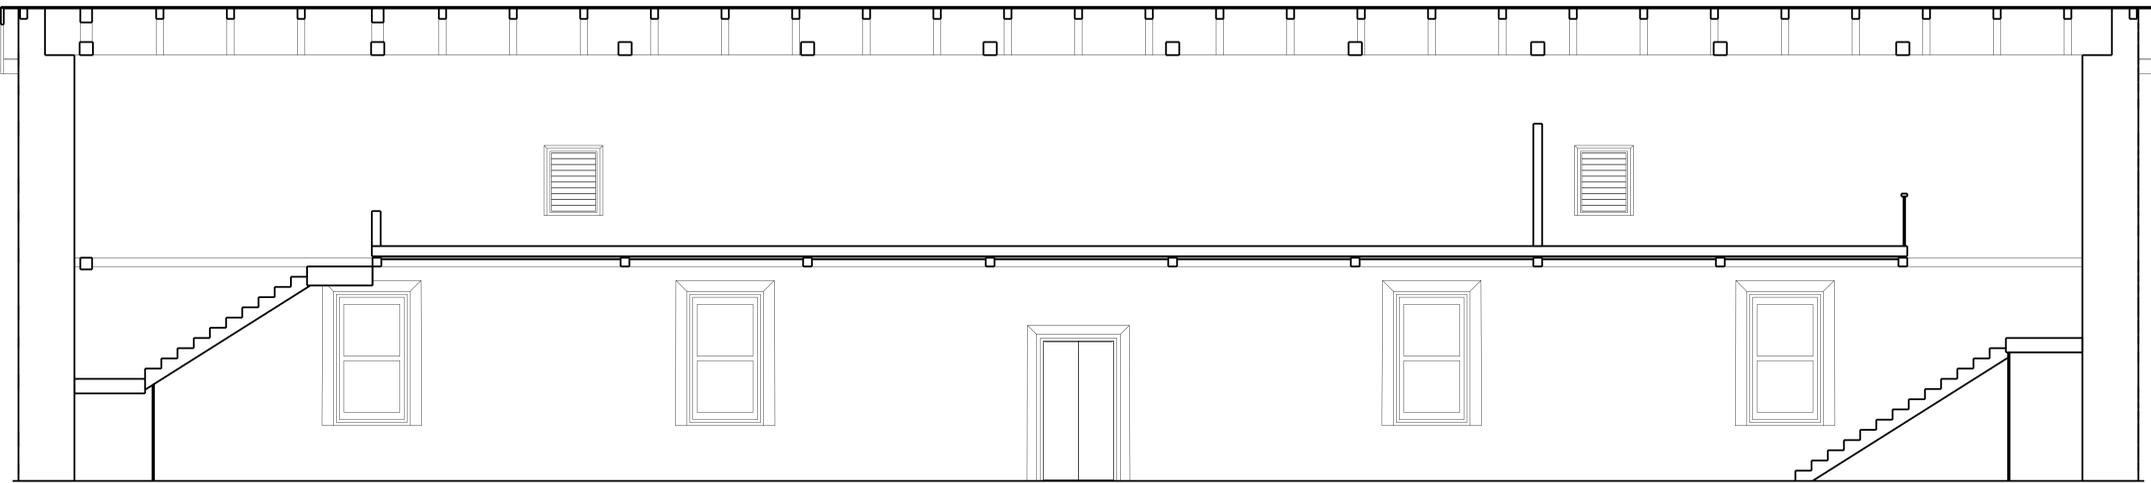

**ELEVATION A-1**  
SCALE: 1/4"=1'-0"

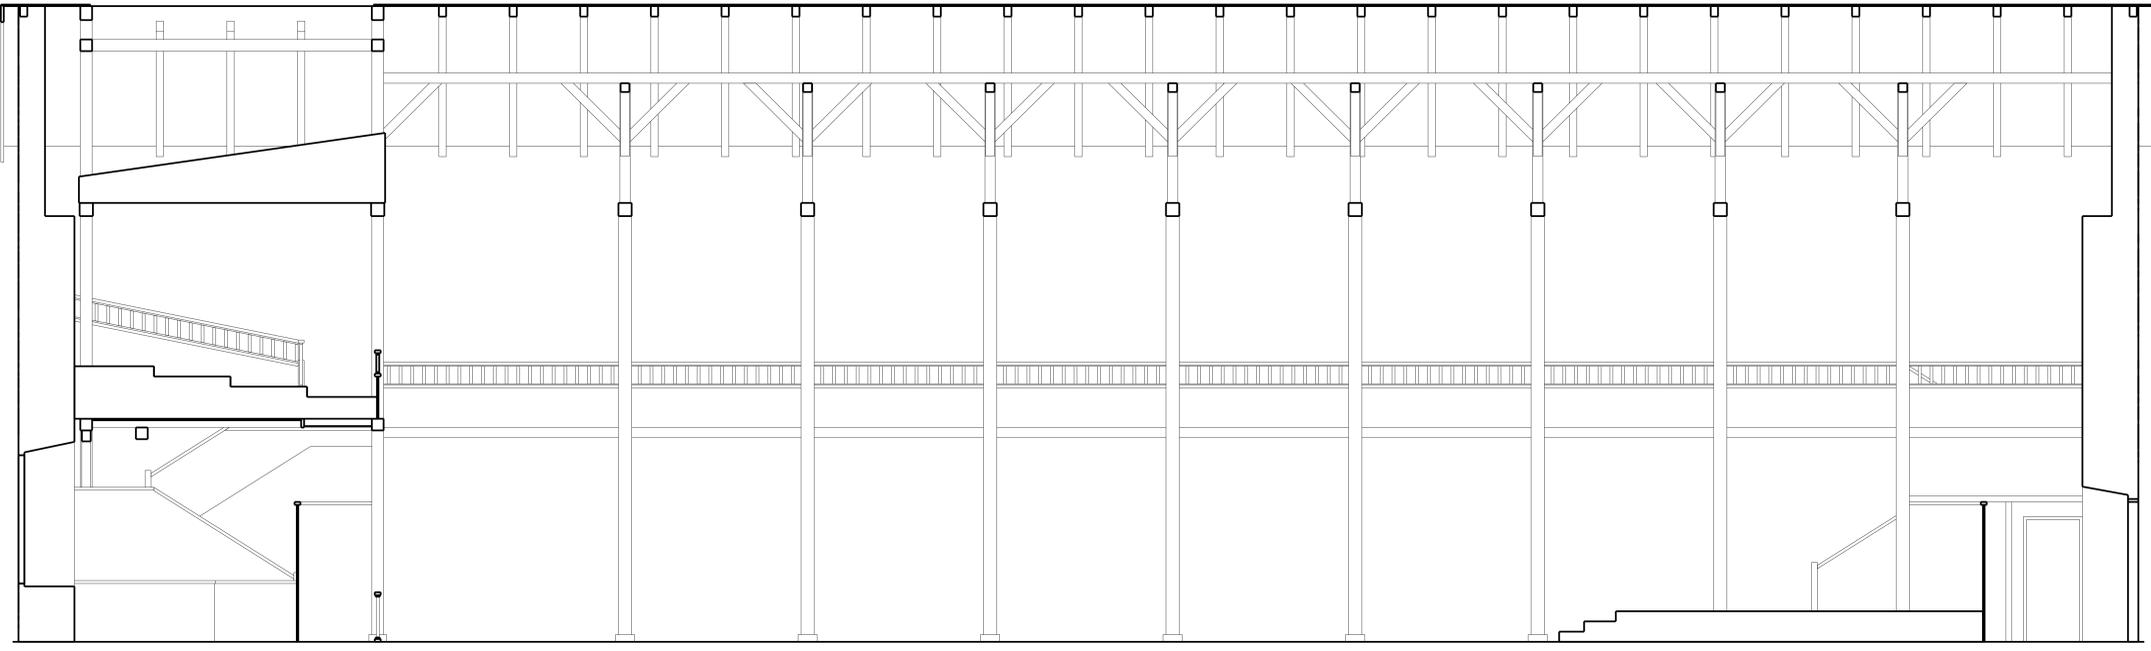


**ELEVATION A-2**  
SCALE: 1/4"=1'-0"

AS BUILT DRAWINGS FOR:  
**MOKUAIKAUA CHURCH**  
KAILUA-KONA, HAWAII  
T.M.K. (3) 7-5-07:18 & 45


DRAWN: PJP	JOB #: 2006-009
DATE: 2/21/2007	
SCALE: 1/4"=1'-0"	
DRAWING: INTERIOR ELEVATIONS	
SHEET	
<b>A7</b>	
8 OF 14 SHEETS	

REVISIONS	BY

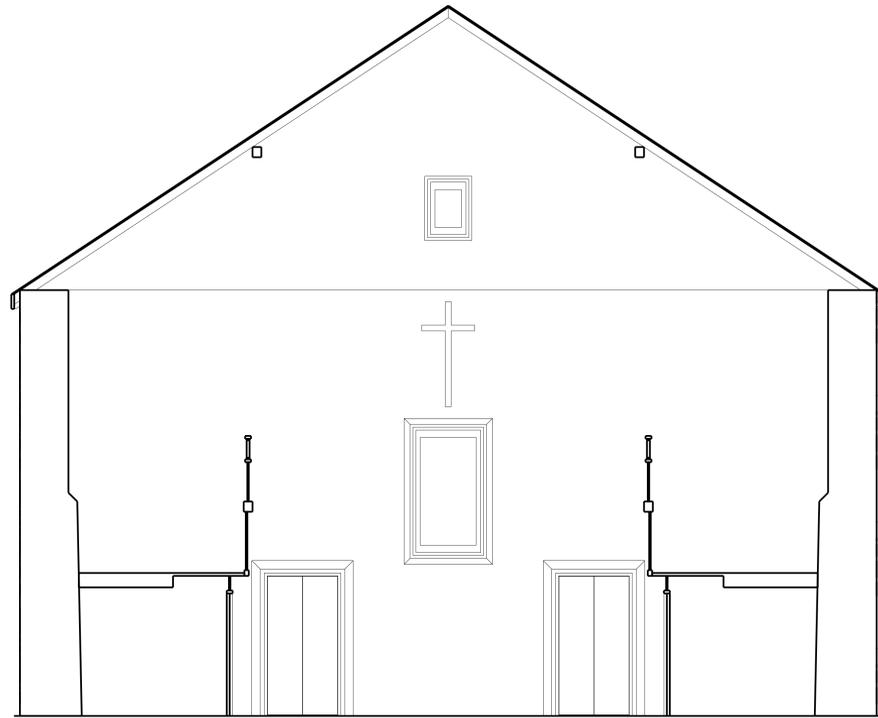


**ELEVATION B-1**

SCALE: 1/4"=1'-0"

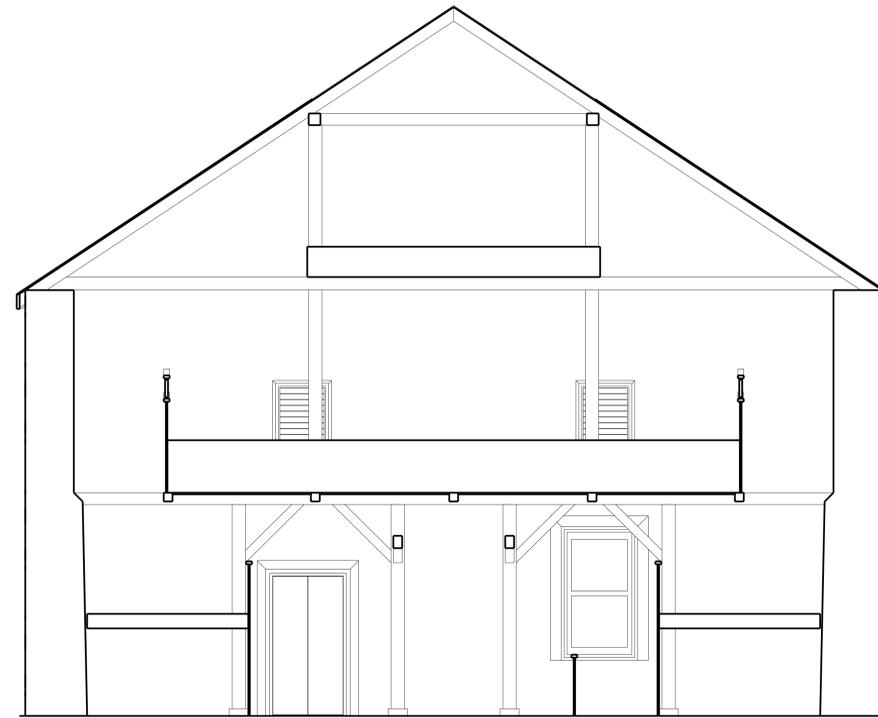


**ELEVATION D-1**

SCALE: 1/4"=1'-0"

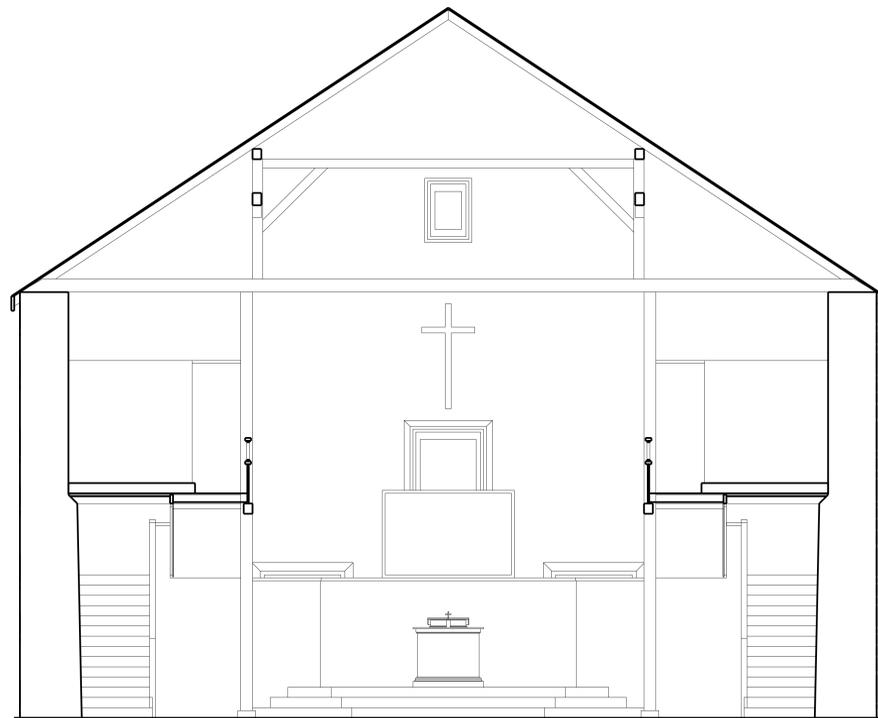

**ELEVATION B-2**

SCALE: 1/4"=1'-0"

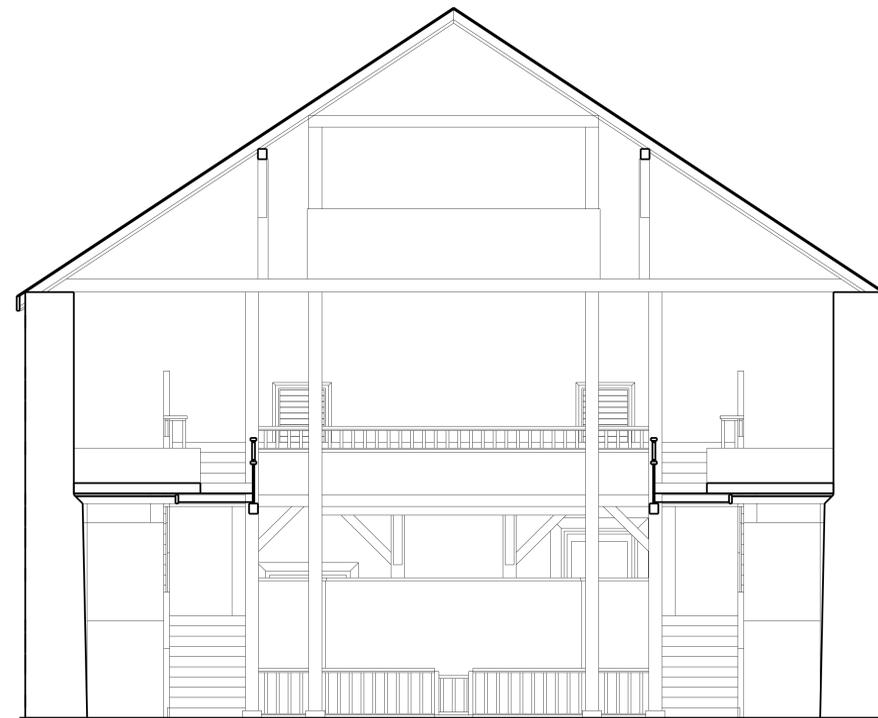

**ELEVATION D-2**

SCALE: 1/4"=1'-0"

**PIPER DESIGNS**

Pete Piper  
75-5044 Kailua Hwy, #2  
Kailua-Kona, HI 96740  
331-2244




AS BUILT DRAWINGS FOR:  
**MOKUAIKAUA CHURCH**  
KAILUA-KONA, HAWAII  
T.M.K. (3) 7-5-07:18 & 45

DRAWN: PJP    JOB #: 2006-009  
DATE: 2/21/2007  
SCALE: 1/4"=1'-0"  
DRAWING:  
INTERIOR ELEVATIONS  
SHEET


**A8**  
9 OF 14 SHEETS

REVISIONS	BY

**PIPER DESIGNS**  
 Pete Piper  
 75-5444 Kailua-Hwy, #2  
 Kailua-Kona, HI 96740  
 331-2244

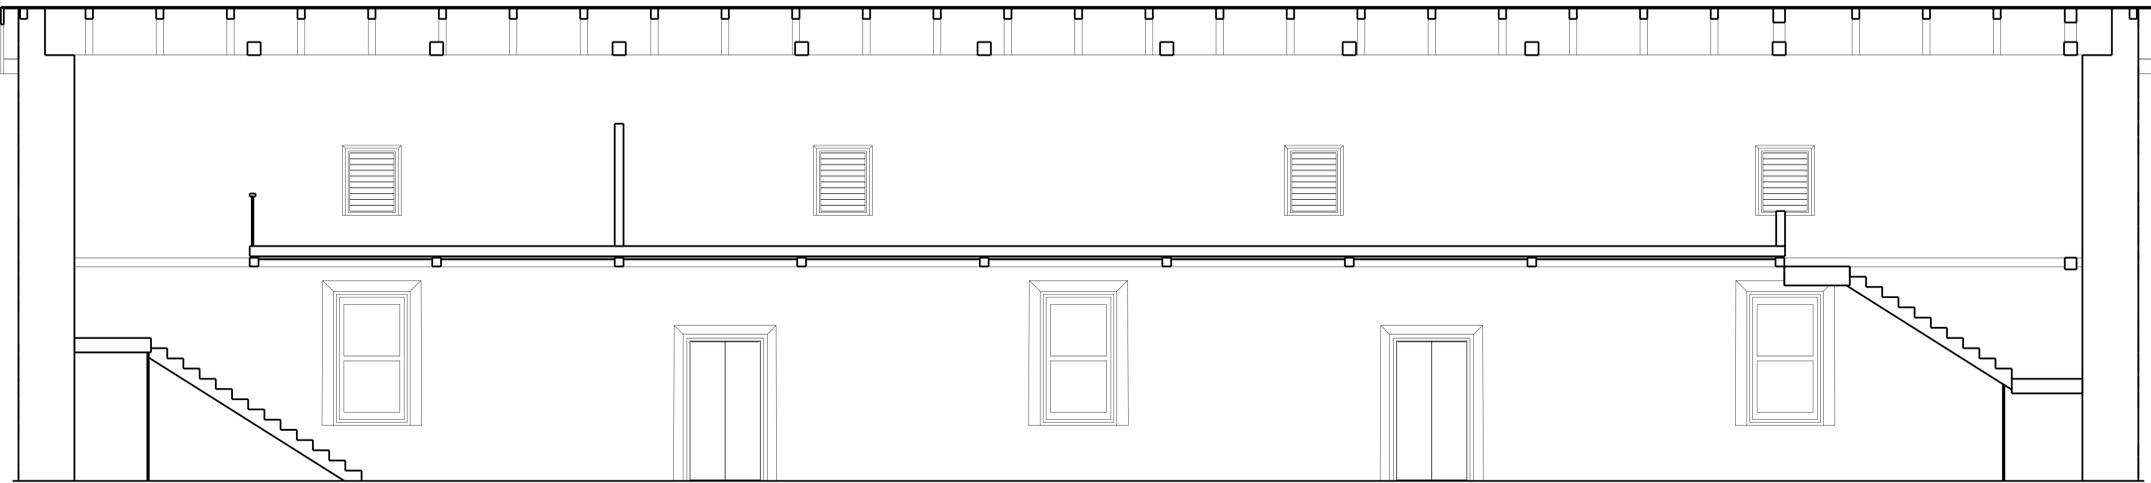

**ELEVATION C-1**  
 SCALE: 1/4"=1'-0"

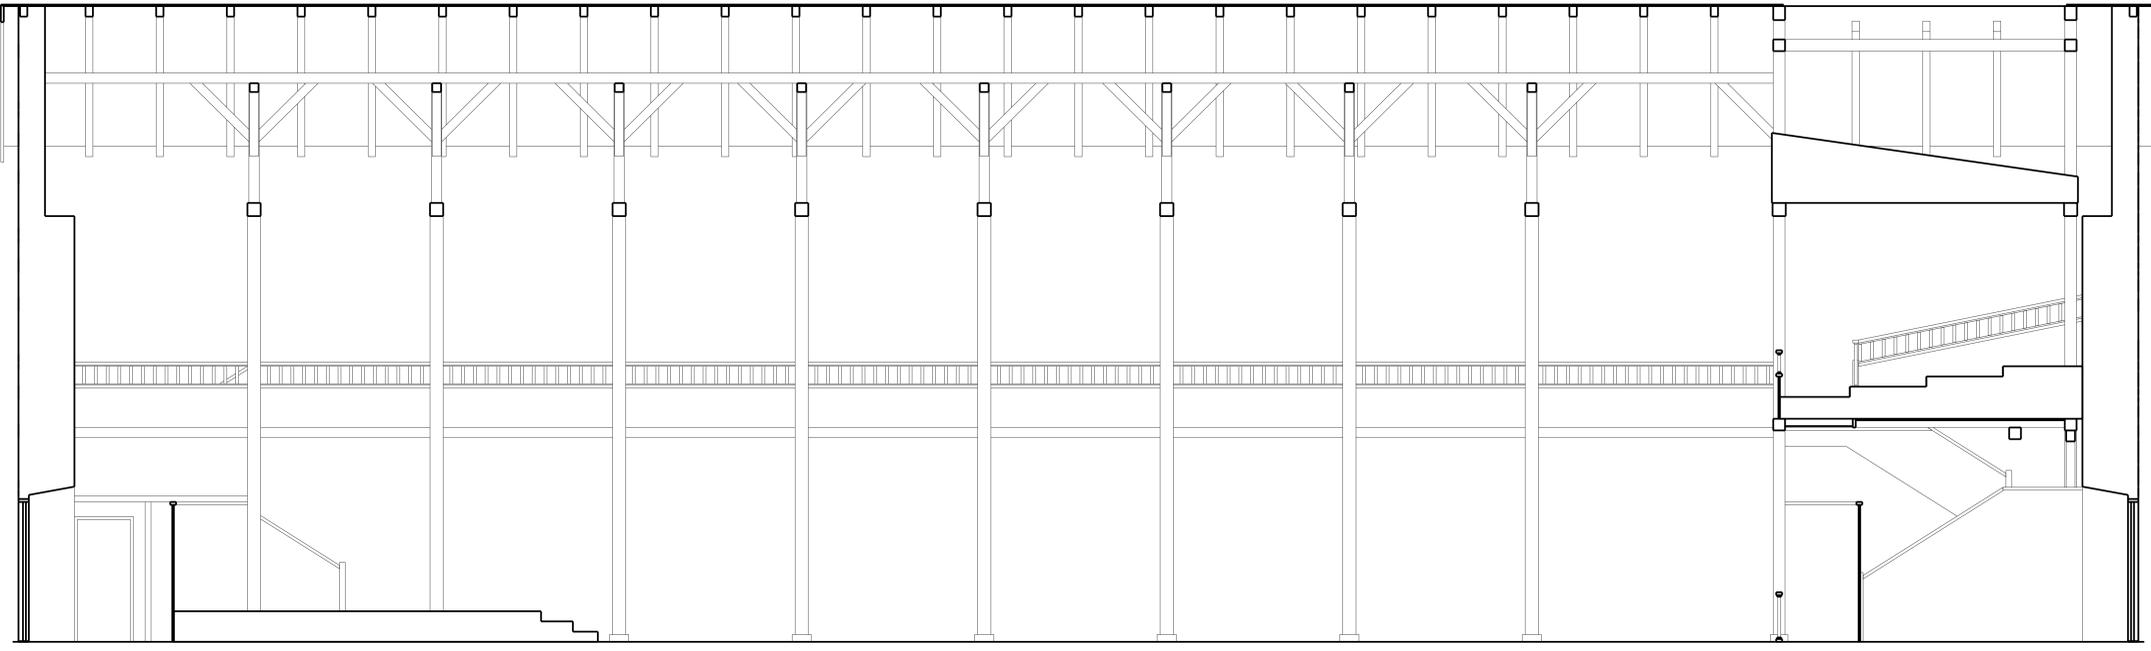


**ELEVATION C-2**  
 SCALE: 1/4"=1'-0"

AS BUILT DRAWINGS FOR:  
**MOKUAIKAUA CHURCH**  
 KAILUA-KONA, HAWAII  
 T.M.K. (3) 7-5-07:18 & 45

DRAWN: PJP	JOB #: 2006-009
DATE: 2/21/2007	
SCALE: 1/4"=1'-0"	
DRAWING: INTERIOR ELEVATIONS	
SHEET	
<b>A9</b>	
10 OF 14 SHEETS	

REVISIONS	BY


**PIPER DESIGNS**  
 Pete Piper  
 75-5444 Kailua-Hwy. #2  
 Kailua-Kona, HI 96740  
 331-2244

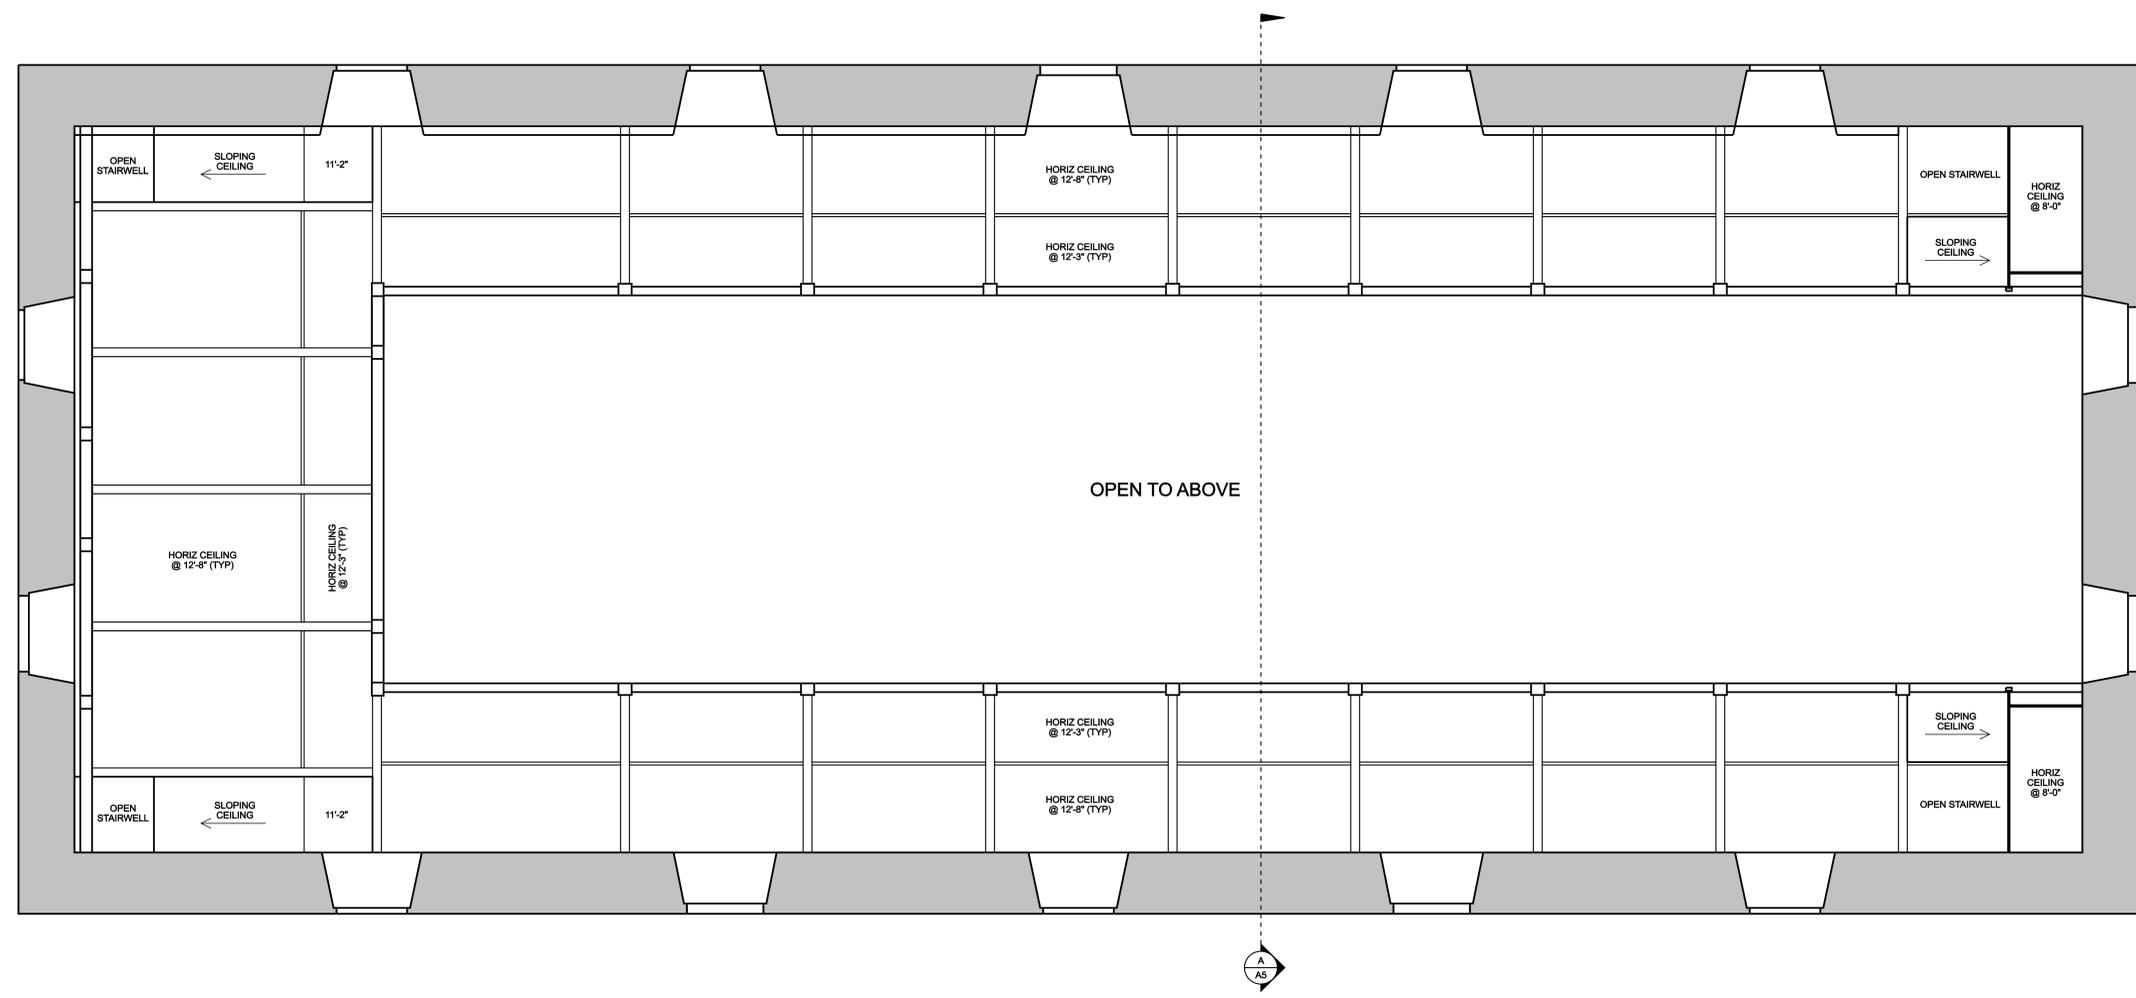

**REFLECTED CEILING PLAN (1ST FLOOR)**  
 SCALE: 1/4"=1'-0"

AS BUILT DRAWINGS FOR:  
**MOKUAIKAUA CHURCH**  
 KAILUA-KONA, HAWAII  
 T.M.K. (3) 7-5-07:18 & 45

DRAWN: PJP	JOB #: 2006-009
DATE: 2/21/2007	
SCALE: 1/4"=1'-0"	
DRAWING: REFLECTED CEILING PLAN (1ST FLOOR)	
SHEET	
<b>A10</b>	
11 OF 14 SHEETS	

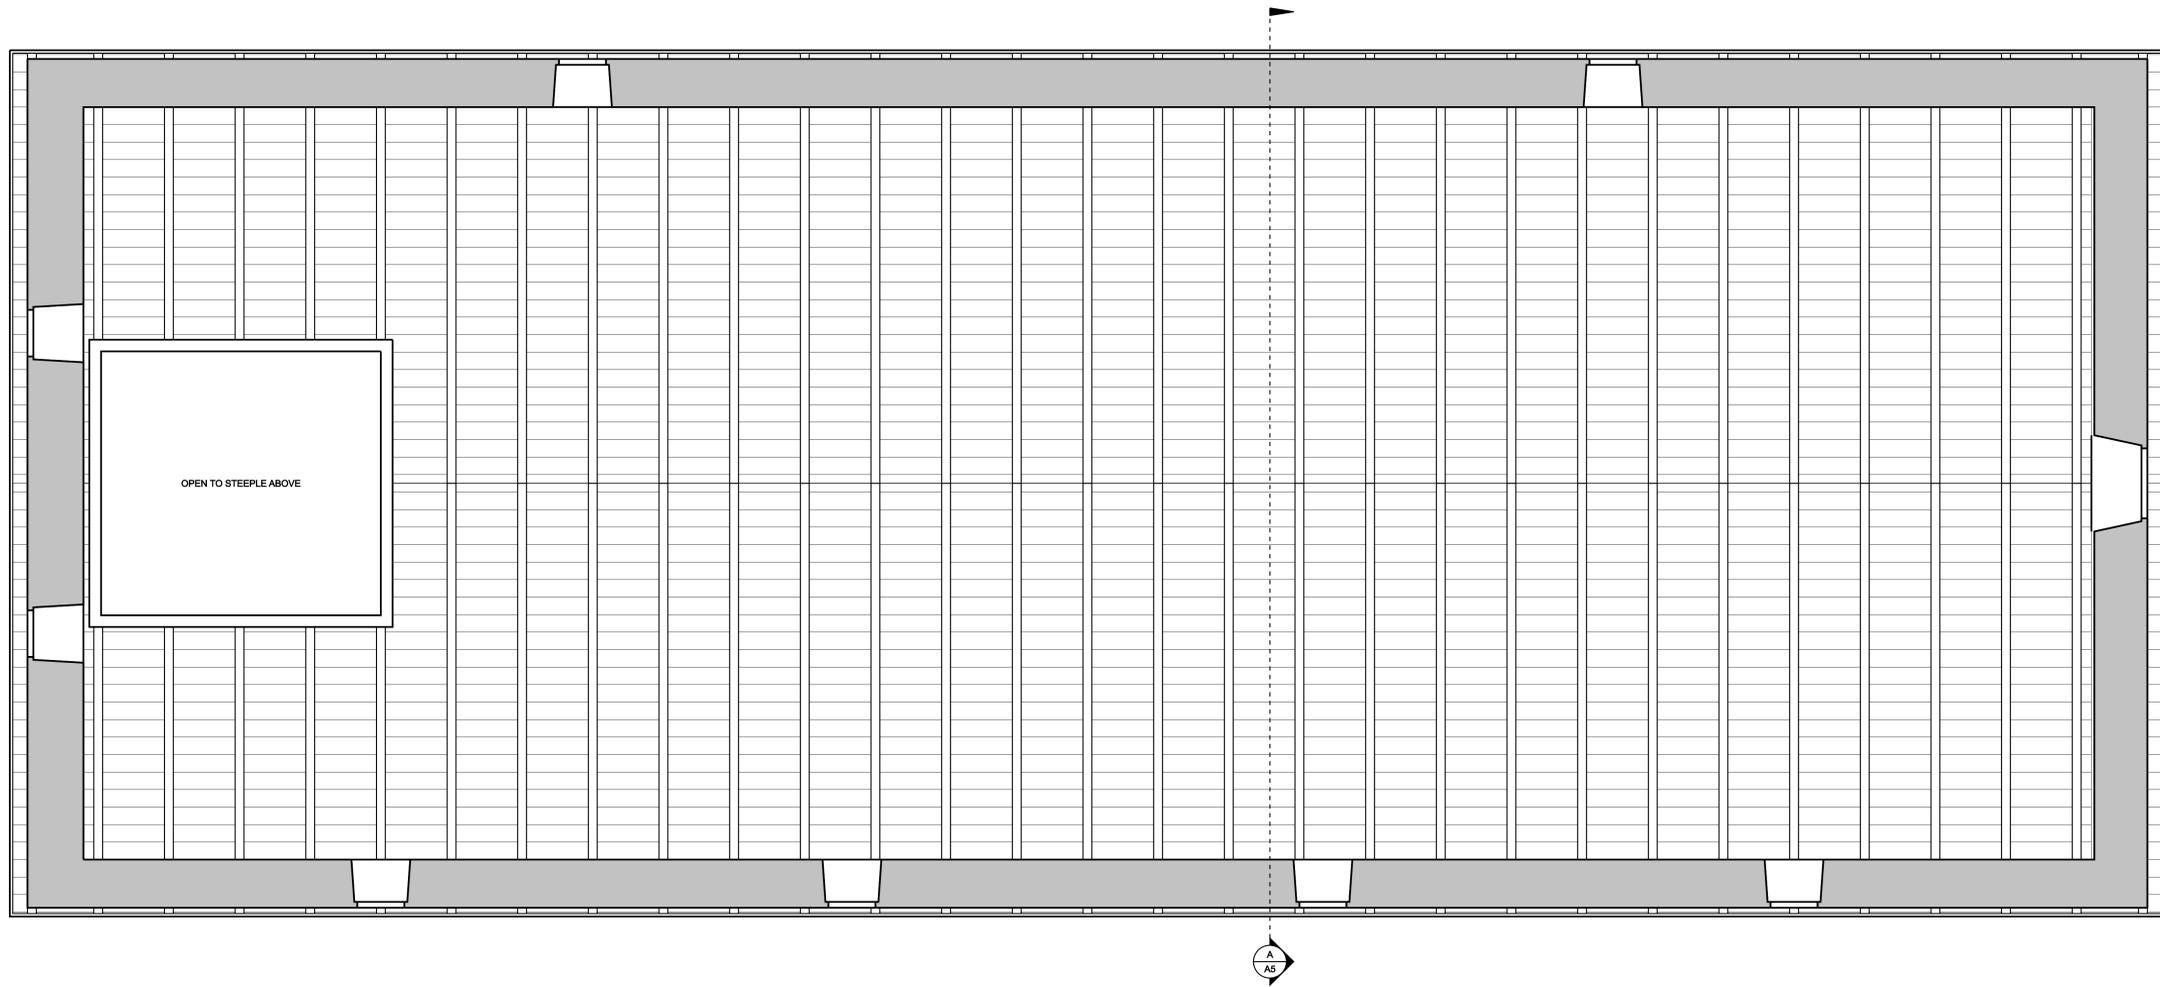

**REFLECTED CEILING PLAN (2ND FLOOR)**

SCALE: 1/4"=1'-0"

REVISIONS	BY

**PIPER DESIGNS**

Pete Piper  
75-5044 Kailua Hwy, #2  
Kailua-Kona, HI 96740  
331-2244


AS BUILT DRAWINGS FOR:  
**MOKUAIKAUA CHURCH**  
KAILUA-KONA, HAWAII  
T.M.K. (3) 7-5-07:18 & 45

DRAWN: PJP	JOB #: 2006-009
DATE: 2/21/2007	
SCALE: 1/4"=1'-0"	
DRAWING: REFLECTED CEILING PLAN (2ND FLOOR)	
SHEET	
<b>A11</b>	
12 OF 14 SHEETS	

REVISIONS	BY

**PIPER DESIGNS**  
 Pete Piper  
 75-5444 Kailua Hwy, #2  
 Kailua-Kona, HI 96740  
 331-2244

LEGEND	LEGEND	LEGEND
<b>ELECTRICAL</b>	<b>LIGHTING</b>	<b>AUDIO / VISUAL</b>
⊕ DUPLEX WALL OUTLET	● NEW LIGHT LOCATIONS	△ AV OUTLET
⊕ 4 PLEX WALL OUTLET		○ MICROPHONE LOCATIONS
⊕ DUPLEX FLOOR OUTLET		○ SPEAKER LOCATIONS
○ OTHER		○ WIRELESS
⊕		☆ SOUND AV CONTROL LOCATIONS

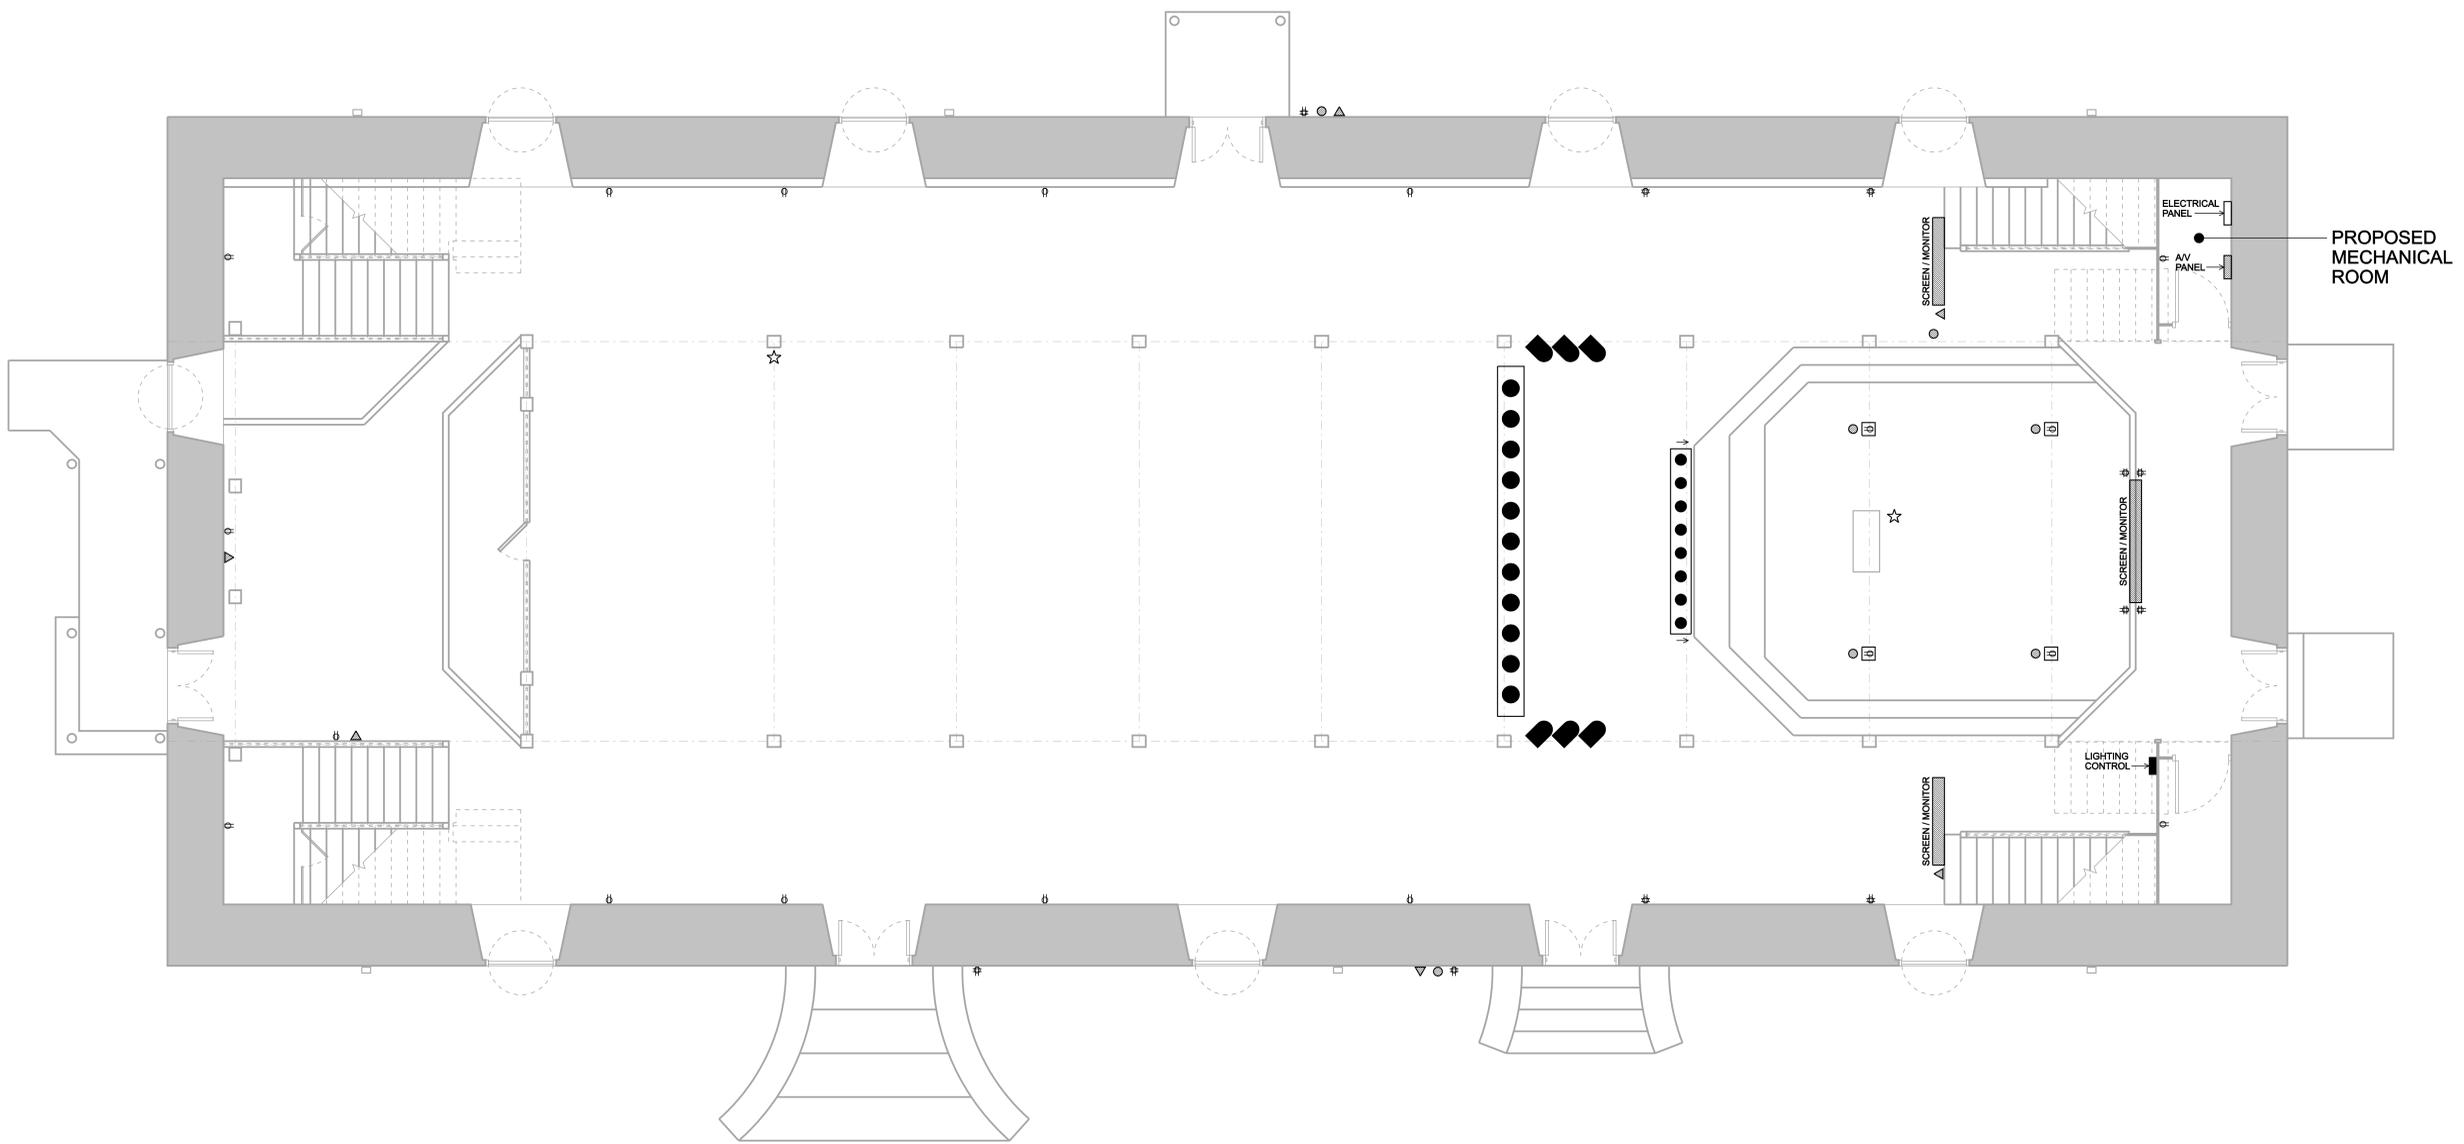

**ELECTRICAL PLAN (1ST FLOOR)**

SCALE: 1/4"=1'-0"

AS BUILT DRAWINGS FOR:  
**MOKUAIKAUA CHURCH**  
 KAILUA-KONA, HAWAII  
 T.M.K. (3) 7-5-07:18 & 45

DRAWN: PJP	JOB #: 2006-009
DATE: 2/21/2007	
SCALE: 1/4"=1'-0"	
DRAWING: ELECTRICAL PLAN (1ST FLOOR)	
SHEET	
<b>E1</b>	
13 OF 14 SHEETS	


REVISIONS	BY

**PIPER DESIGNS**  
 Pete Piper  
 75-5444 Kailua-Hwy. #2  
 Kailua-Kona, HI 96740  
 331-2244

**LEGEND**  
**ELECTRICAL**  
 Ⓟ DUPLEX WALL OUTLET  
 Ⓢ 4 PLEX WALL OUTLET  
 Ⓛ DUPLEX FLOOR OUTLET  
 ○ OTHER  
 Ⓜ

**LEGEND**  
**LIGHTING**  
 ● NEW LIGHT LOCATIONS

**LEGEND**  
**AUDIO / VISUAL**  
 ▲ AV OUTLET  
 ⊙ MICROPHONE LOCATIONS  
 ⊙ SPEAKER LOCATIONS  
 ○ WIRELESS  
 ☆ SOUND AV CONTROL LOCATIONS

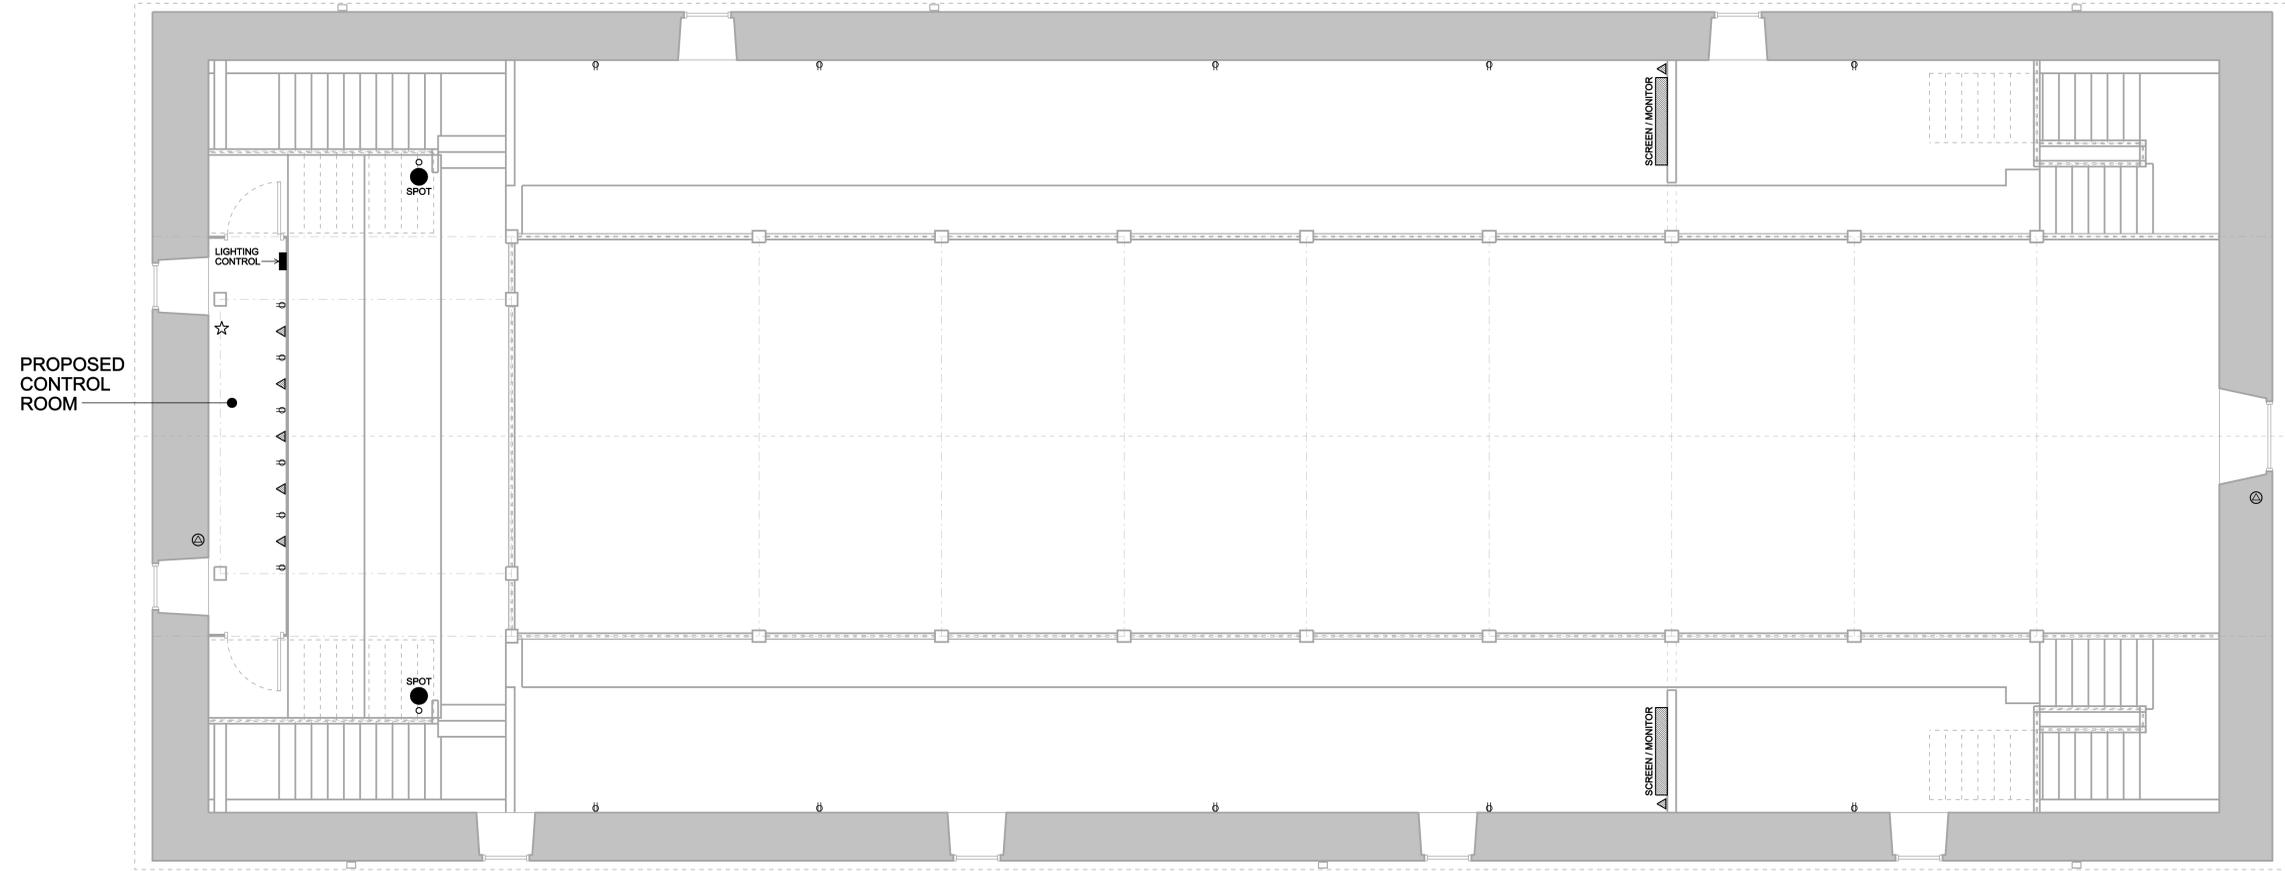

**ELECTRICAL PLAN (2ND FLOOR)**  
 SCALE: 1/4"=1'-0"

AS BUILT DRAWINGS FOR:  
**MOKUAIKAUA CHURCH**  
 KAILUA-KONA, HAWAII  
 T.M.K. (3) 7-5-07:18 & 45

DRAWN: PJP	JOB #: 2006-009
DATE: 2/21/2007	
SCALE: 1/4"=1'-0"	
DRAWING: ELECTRICAL PLAN (2ND FLOOR)	
SHEET	
<b>E2</b>	
14 OF 14 SHEETS	